




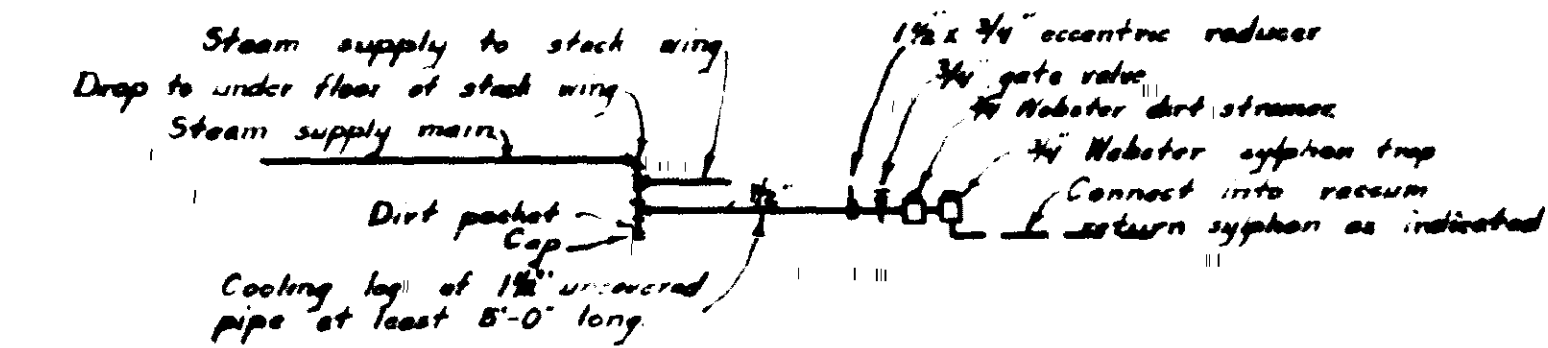

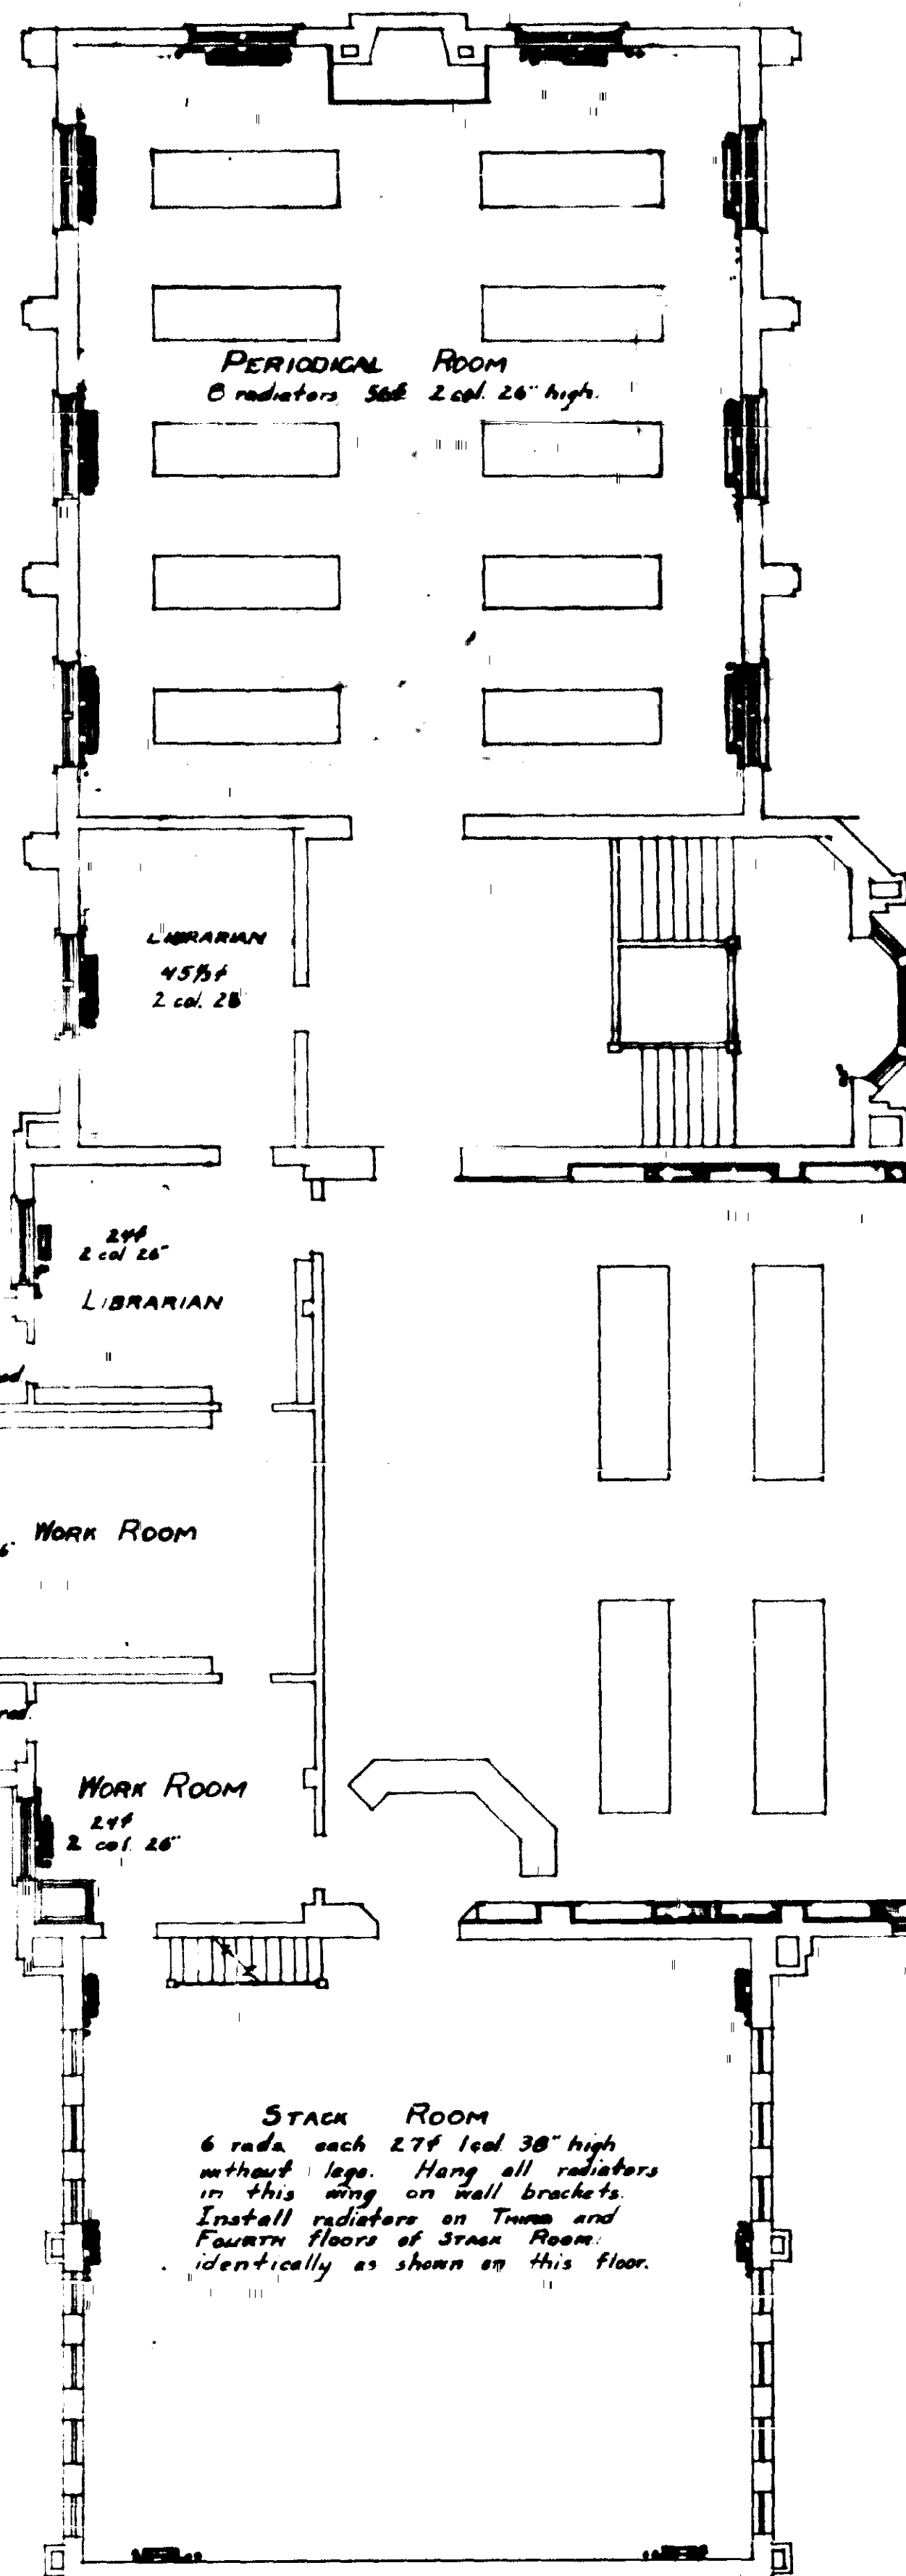

ELEVATION - CONNECTIONS AT DRIP POINT IN SUPPLY MAIN NEAR STACK ROOM
No scale.

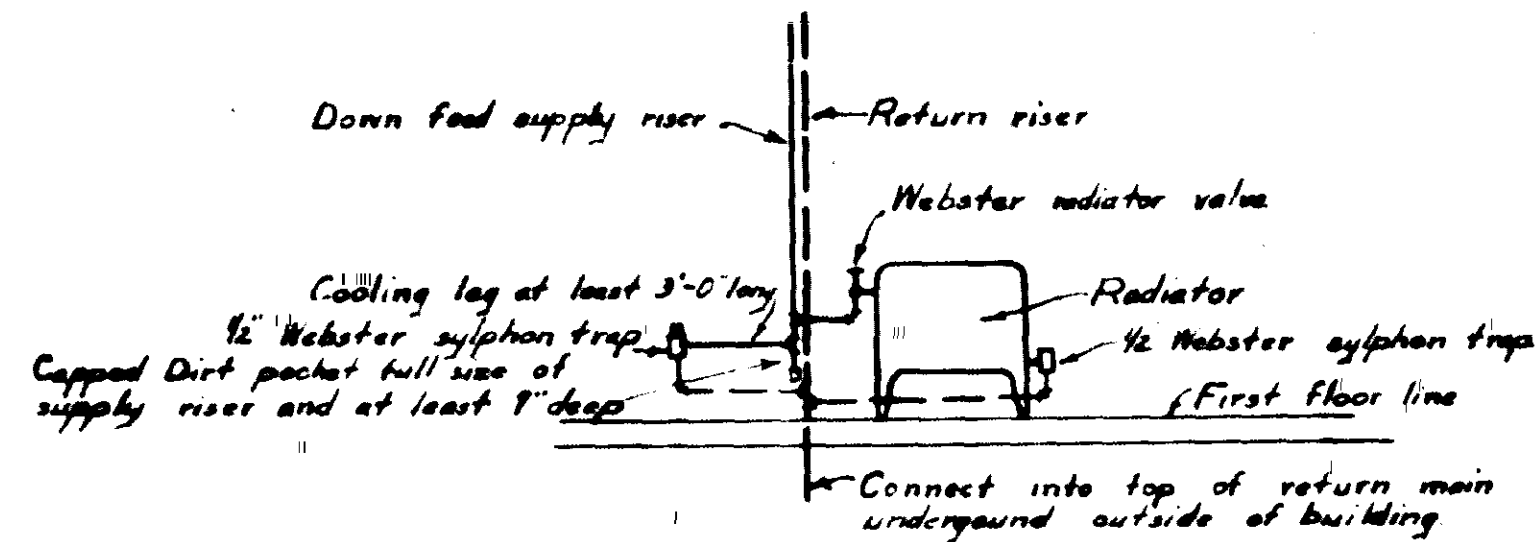

ELEVATION - DOWN FEED SUPPLY RISER DRIPS
No scale.

18 radi. in wall pockets under windows. Each radiator 80" 3 column 38" high. Wall pockets must be 14" deep. Install valves and traps at same end of all concealed radiators in this room. Recesses for concealed radiators and all grilles will be provided under a separate contract. Refer to Architects plans for radiator enclosures.


SECOND FLOOR PLAN.
Scale 1/8" = 1'-0"

Lateral connections from risers to radiators must be made near floor, must be one size larger than radiator valves and traps and must be graded back to risers at least 1" in every 5'-0". Risers will be run exposed except where otherwise noted.

NO.	DATE	BY	FOR
11	10-20-26	J. W.	PLAN
12	10-20-26	J. W.	PLAN
13	10-20-26	J. W.	PLAN
14	10-20-26	J. W.	PLAN
15	10-20-26	J. W.	PLAN
16	10-20-26	J. W.	PLAN
17	10-20-26	J. W.	PLAN
18	10-20-26	J. W.	PLAN
19	10-20-26	J. W.	PLAN
20	10-20-26	J. W.	PLAN
21	10-20-26	J. W.	PLAN
22	10-20-26	J. W.	PLAN
23	10-20-26	J. W.	PLAN
24	10-20-26	J. W.	PLAN
25	10-20-26	J. W.	PLAN
26	10-20-26	J. W.	PLAN
27	10-20-26	J. W.	PLAN
28	10-20-26	J. W.	PLAN
29	10-20-26	J. W.	PLAN
30	10-20-26	J. W.	PLAN

LIBRARY BUILDING
UNIVERSITY OF FLORIDA
GAINESVILLE - FLORIDA

FILE NO. 510
DRAWING NO. 12
DATE 4/26
DRAWN BY K.
CHECKED BY
EDWARDS & JAYWARR ARCHITECTS
101 MARIELLA ST. - ATLANTA - GA.

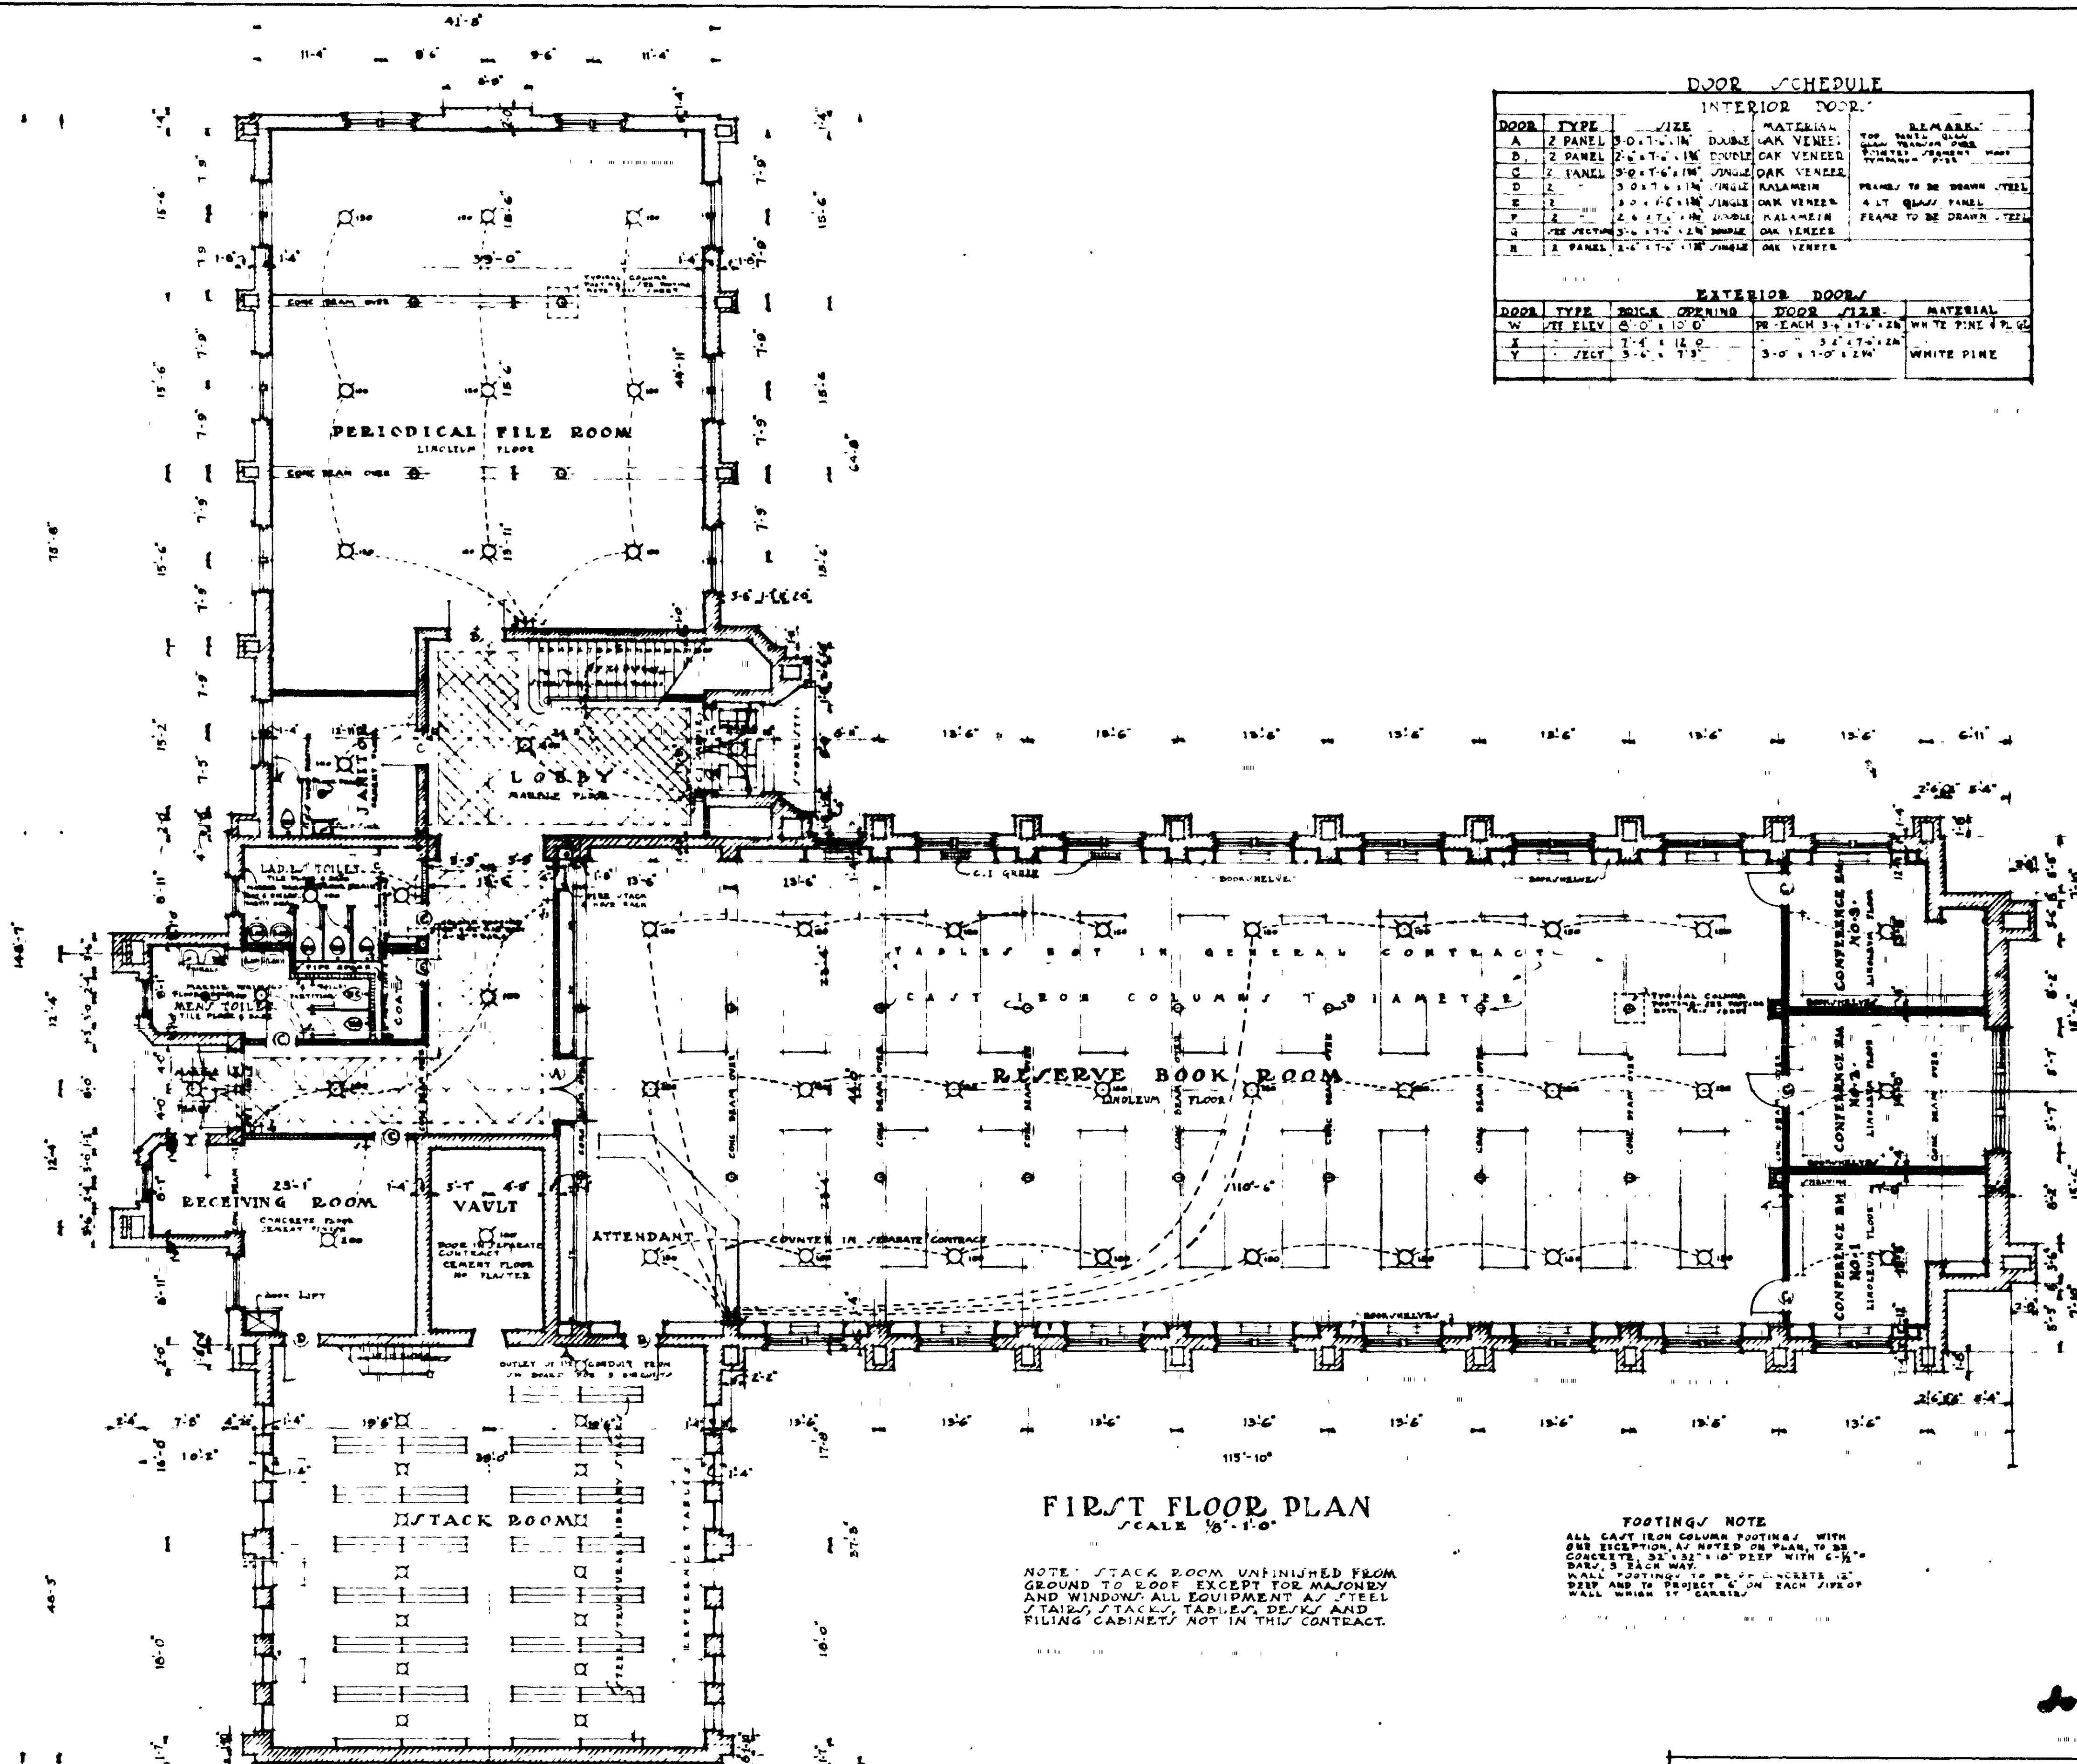


FIRST FLOOR PLAN
 SCALE 1/8" = 1'-0"

NOTE: STACK ROOM UNFINISHED FROM GROUND TO ROOF EXCEPT FOR MASONRY AND WINDOWS. ALL EQUIPMENT AS STEEL STAIRS, STACKS, TABLES, DESKS AND FILING CABINETS NOT IN THIS CONTRACT.

LIBRARY BUILDING
UNIVERSITY OF FLORIDA
 GAINESVILLE - FLORIDA

FILE NO. 520
 DRAWN BY W.R.C. 12/24
 DATE JAN 25-1924
 EDWARDS & JAYWARD - ARCHITECTS
 101 MARIETTA ST. - ATLANTA, GA.

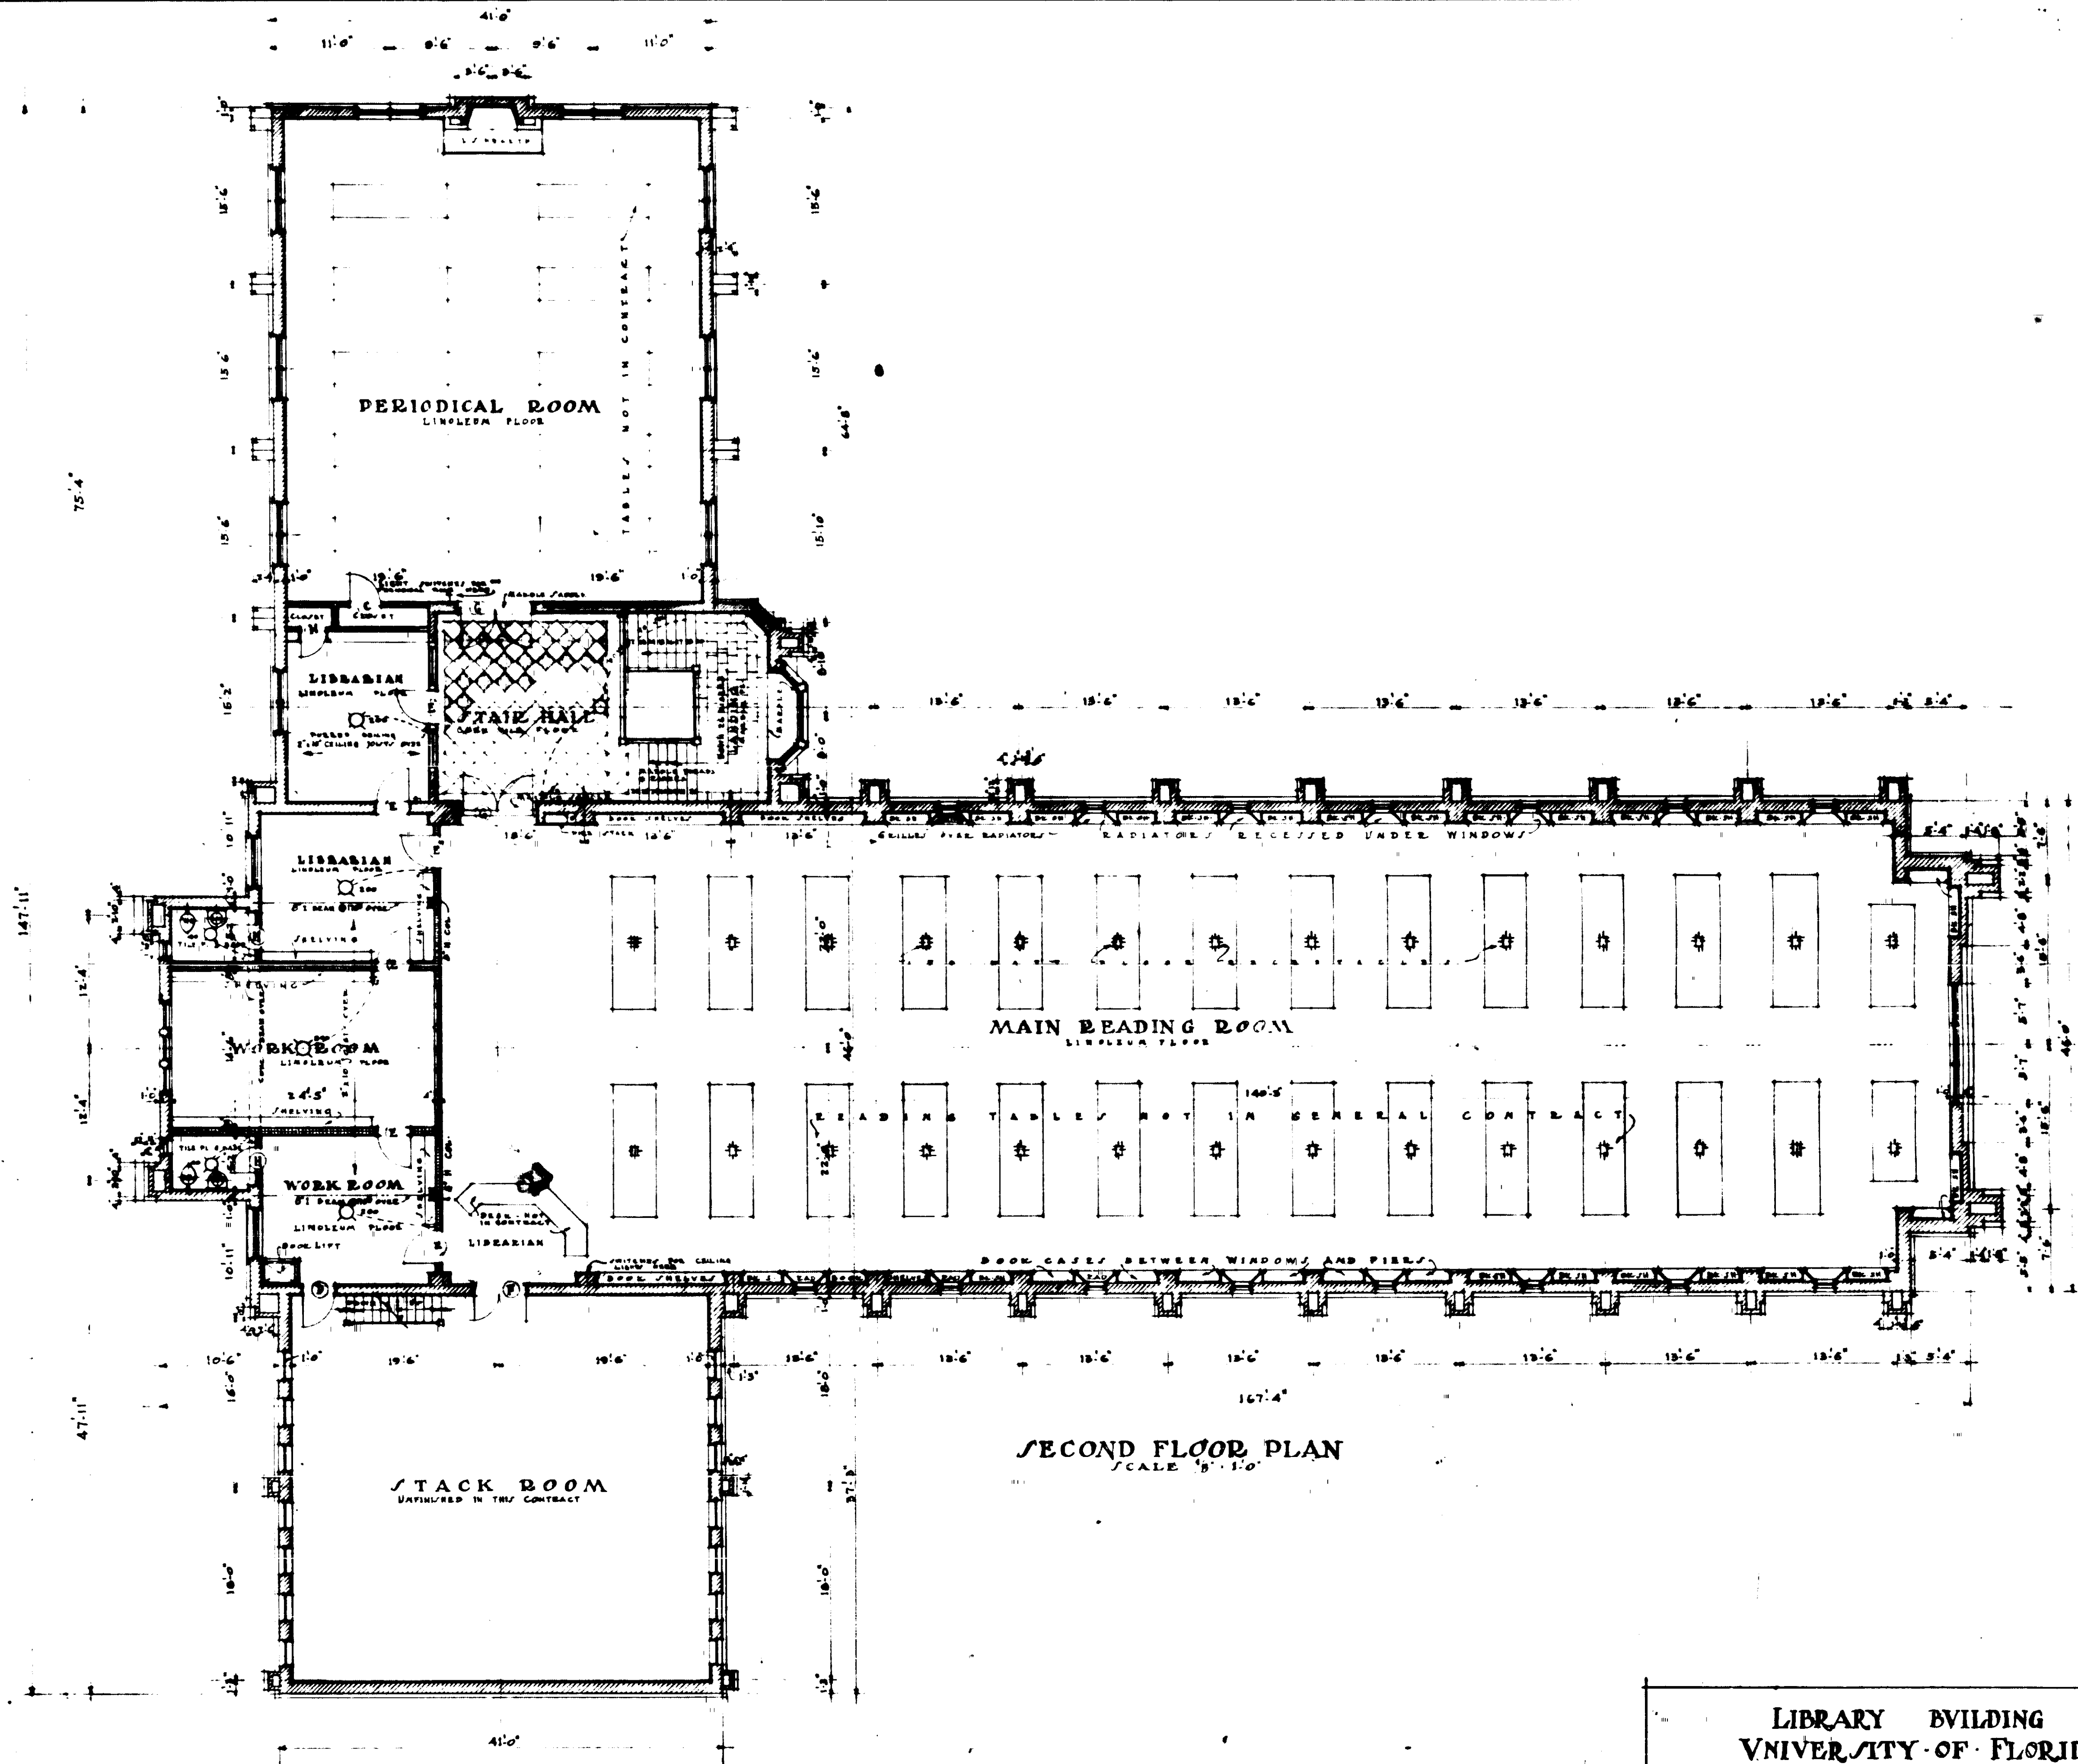


LIBRARY BUILDING
UNIVERSITY OF FLORIDA
GAINESVILLE - FLORIDA

FILE NO 520
DRAWN BY W.E.G.
DRWG NO 2
CHECKED BY L

DATE JAN-25-1924

EDWARDS & SAWYARD - ARCHITECTS
101 MARIETTA ST. ATLANTA, GA.

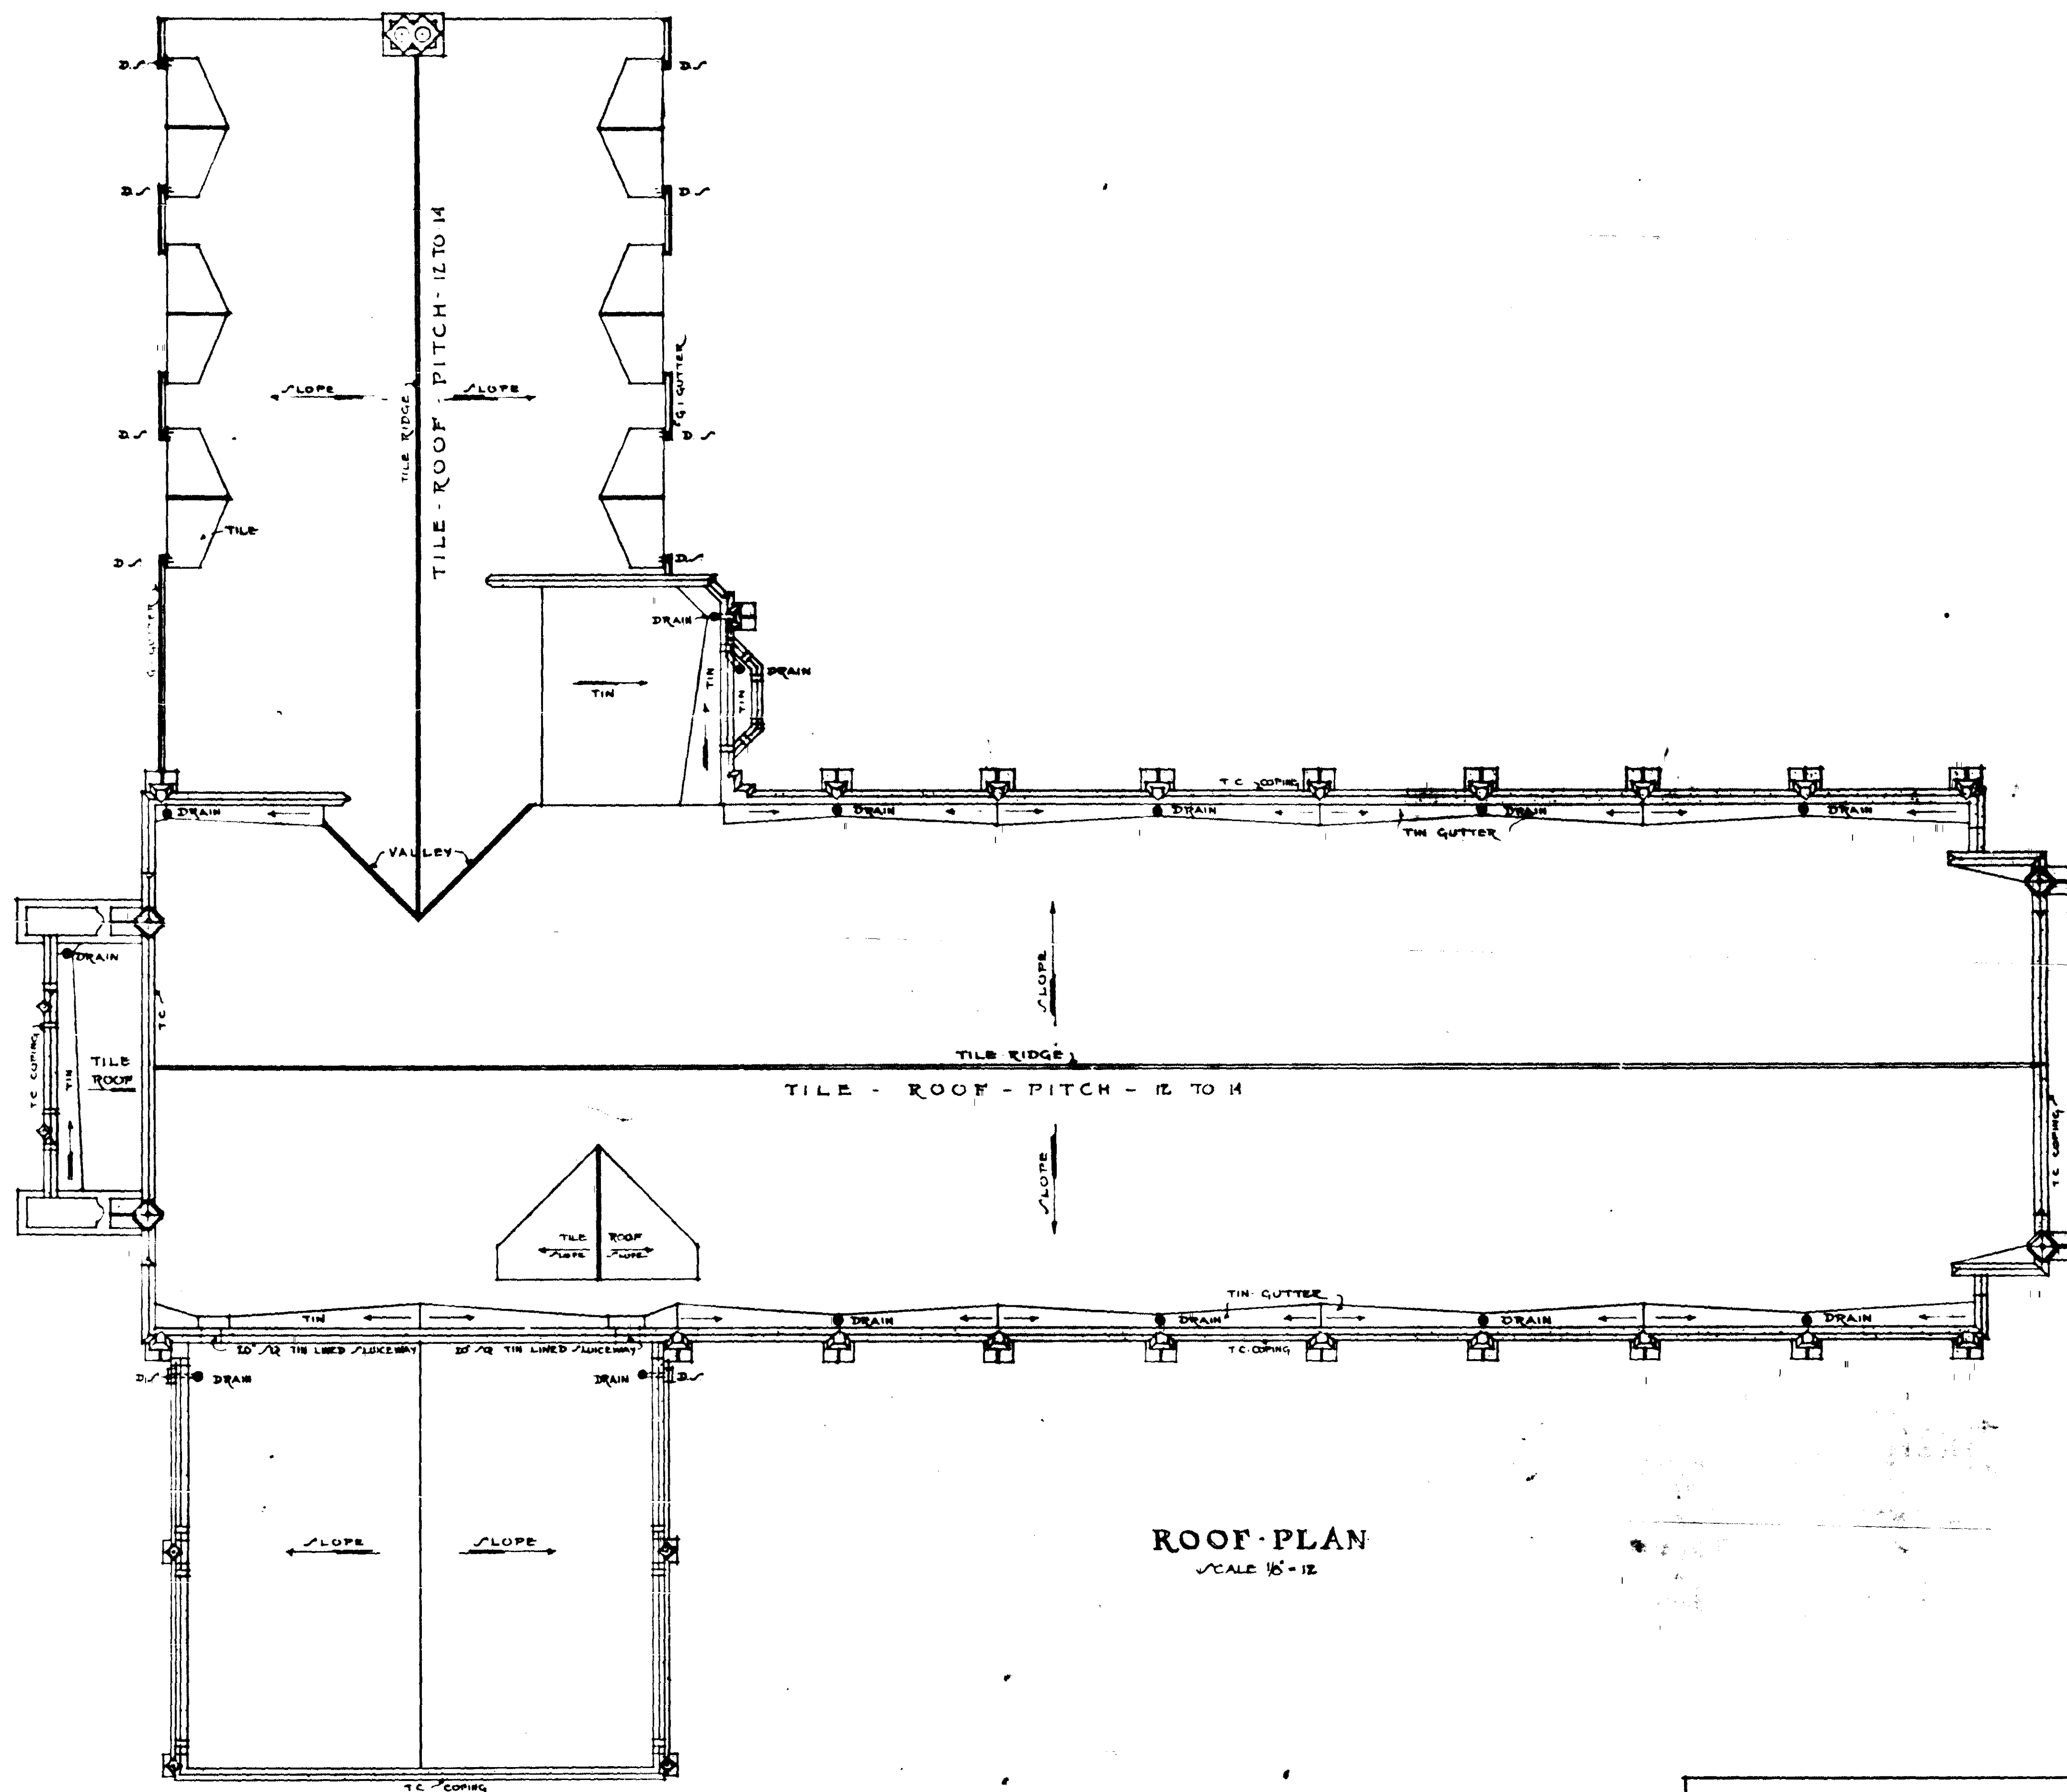

ROOF PLAN
SCALE 1/8" = 1'

LIBRARY BUILDING
UNIVERSITY OF FLORIDA
GAINESVILLE - FLORIDA
FILE NO 520 DRAWN BY R
DWG NO 3 CHECKED BY
DATE JAN 25, 1924
EDWARDS & SAYWARD - ARCHITECTS
101 Marietta St. ATLANTA, GA

NORTH-ELEVATION

Architectural drawing of the second floor and roof of a building. The drawing includes the following annotations and features:

- Roof:** TILED ROOF, PITCH - 12 TO 14.
- Structural Elements:** T.C. (Truss), D.R.C. (Dormer), G.I.D.S. (Gable End), C.I. BOOTS (Cast Iron Boots), CRASSIE (Crassie).
- Windows:** Various window types, including arched windows and multi-paned windows.
- Annotations:**
 - NOTE ALL SILL COPING AND BUTTRESS CAPS TO BE T.C. UNLESS OTHERWISE SHOWN.
 - SCALE 1/8" = 1'-0"
 - SECOND FLOOR LINE
 - 15'-0"
 - 10'-0"
 - 8'-0"
 - 6'-0"
 - 4'-0"
 - 2'-0"
 - 0'-0"
 - BOTTOM OF FOOTING


SOUTH-ELEVATION

LIBRARY · BUILDING
UNIVERSITY · OF · FLORIDA
GAINESVILLE ~ FLORIDA


FILE # 520 DRAWN BY M'LQR
DWG # 5 CHECKED BY

DATE JUN. 23, 1964


EDWARDS & JAYWALK ARCHITECTS
101 MARIETTA ST - ATLANTA, GA

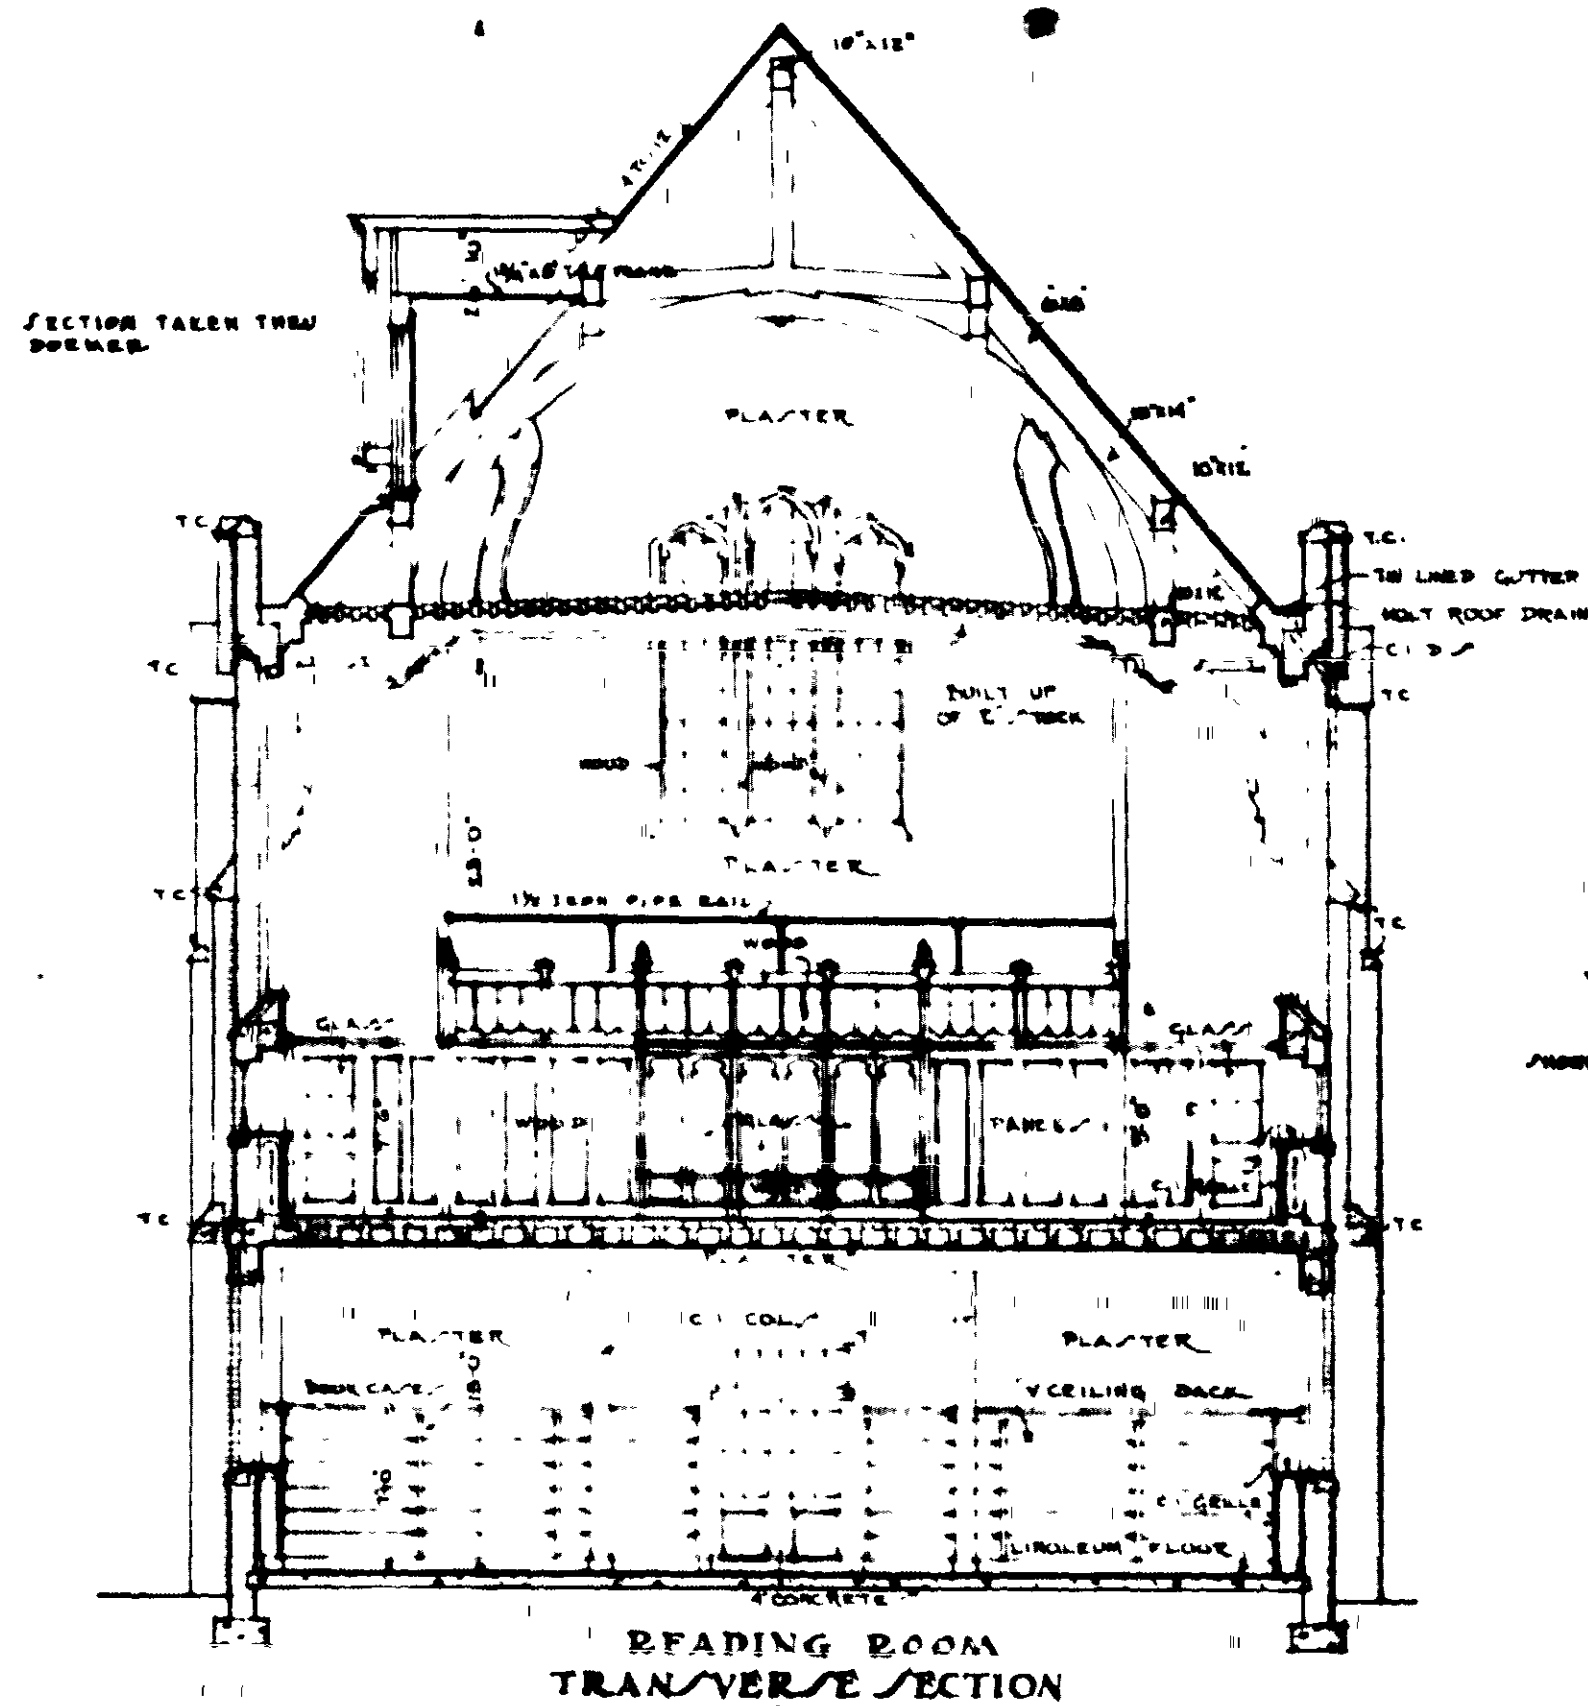


READING ROOM
TRANSVERSE SECTION
SCALE 1/8" = 1'-0"

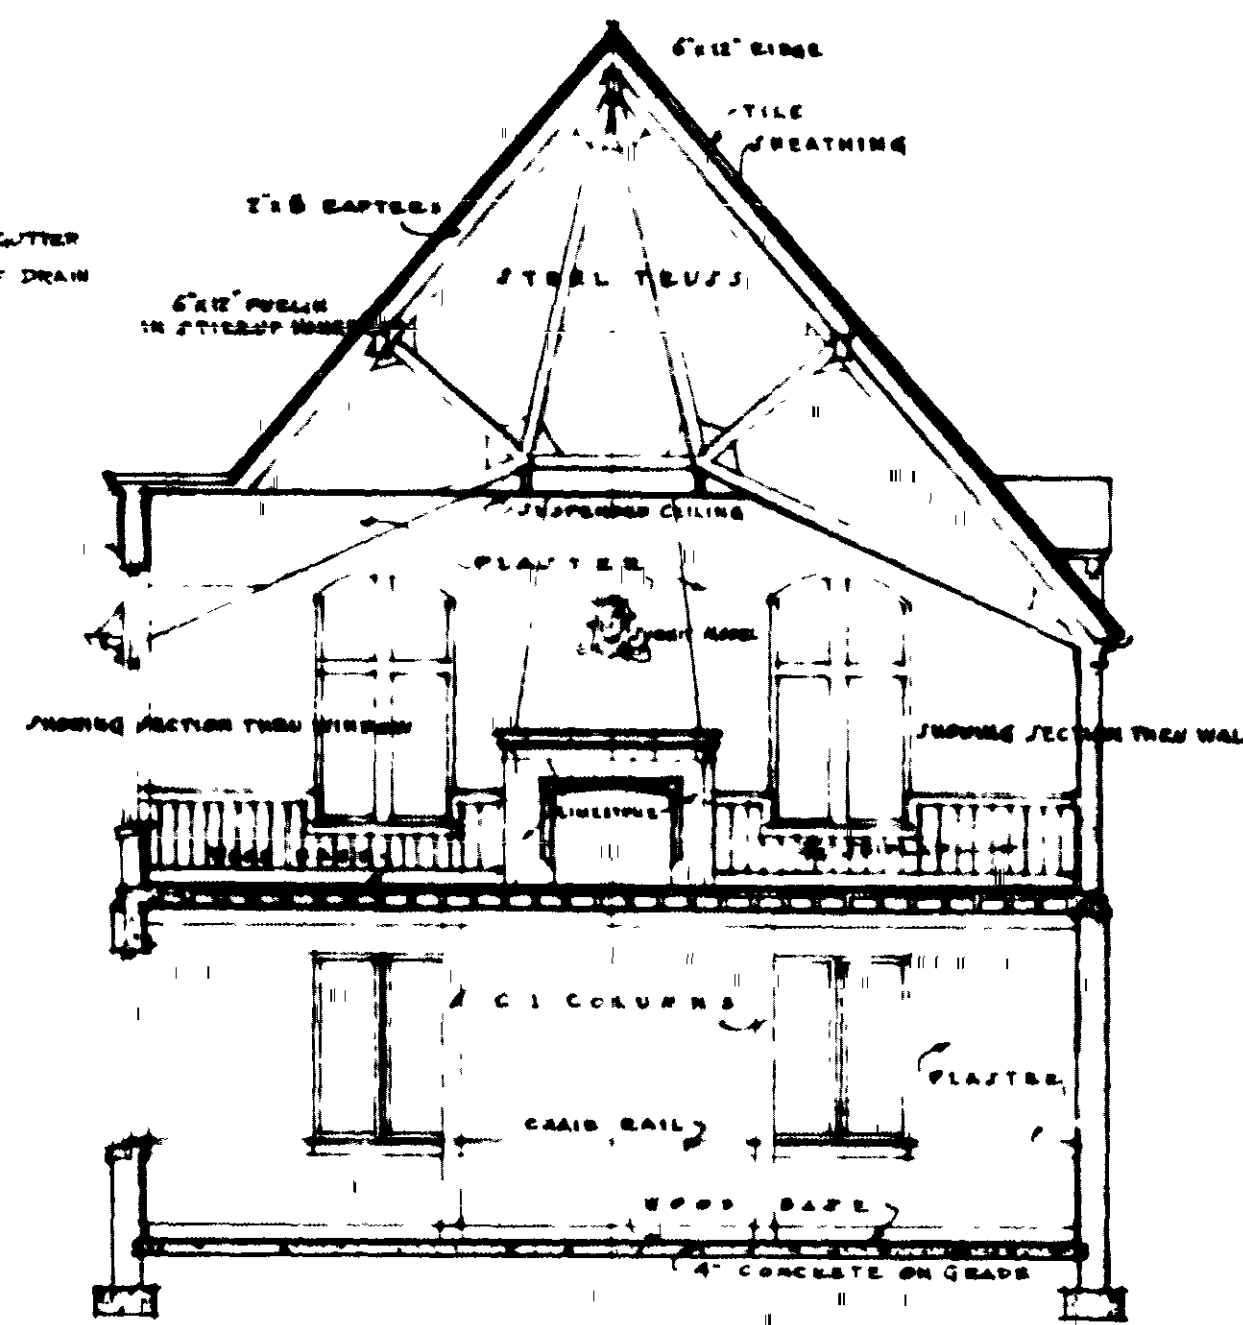

SECTION THRU PERIODICAL ROOM
SCALE 1/8" = 1'-0"

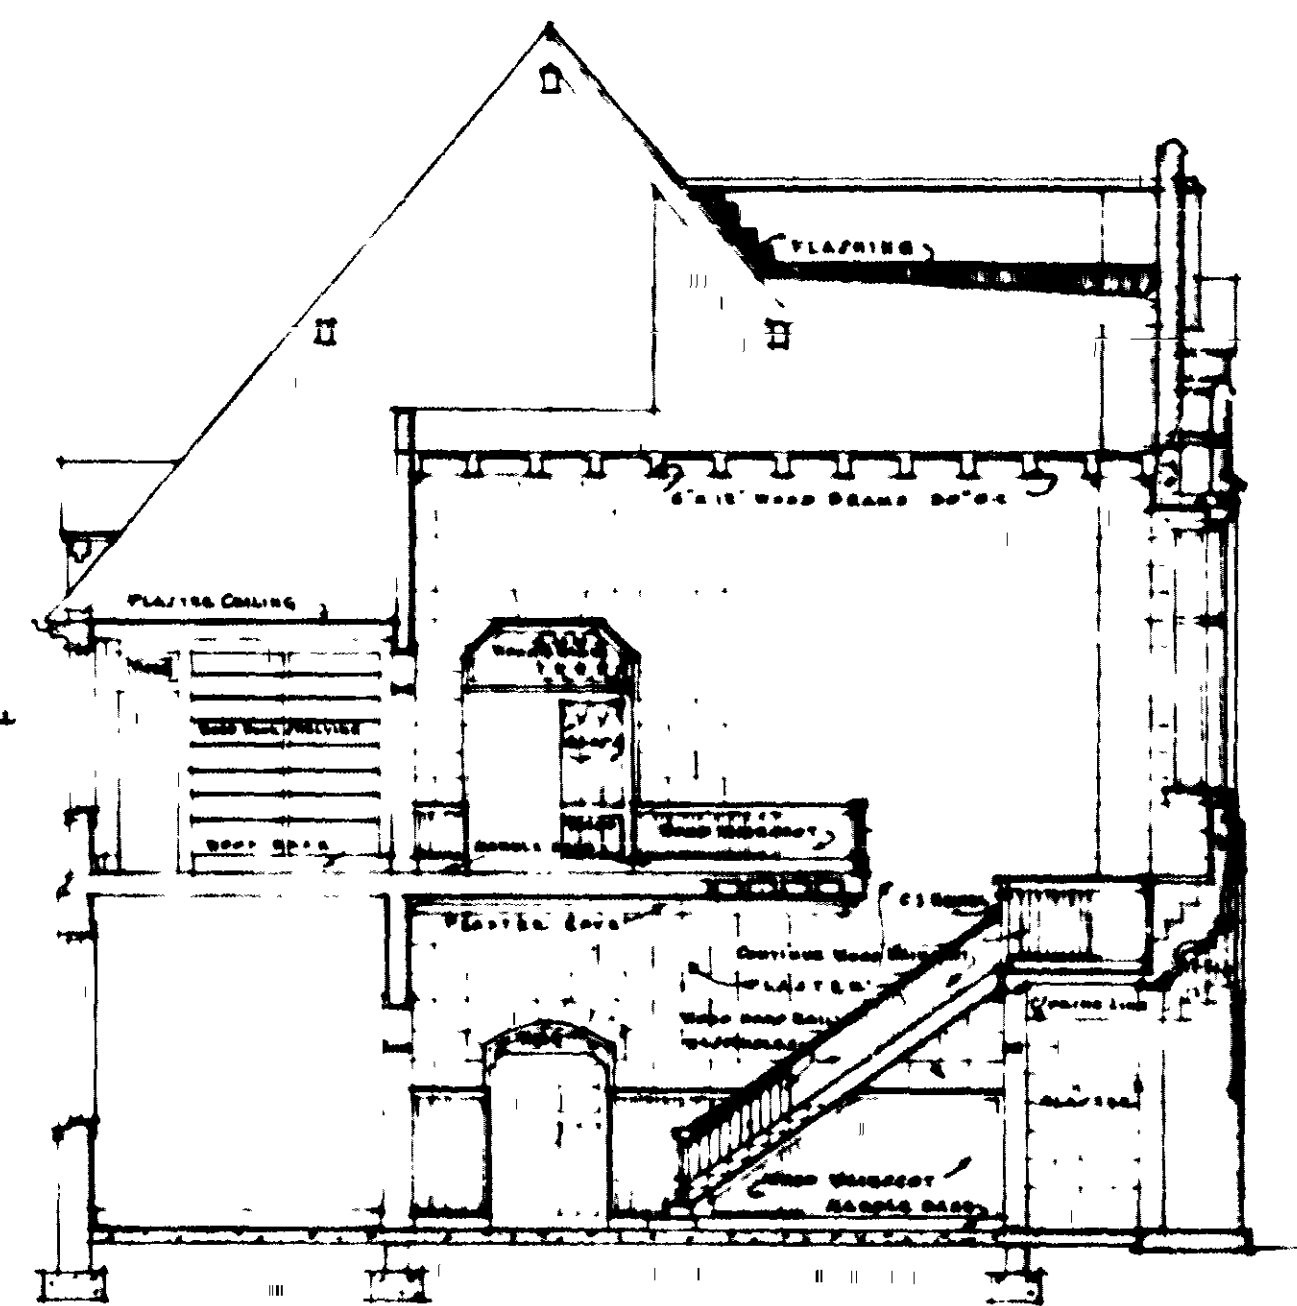



SECTION THRU STAIR HALL
SCALE 1/8" = 1'-0"

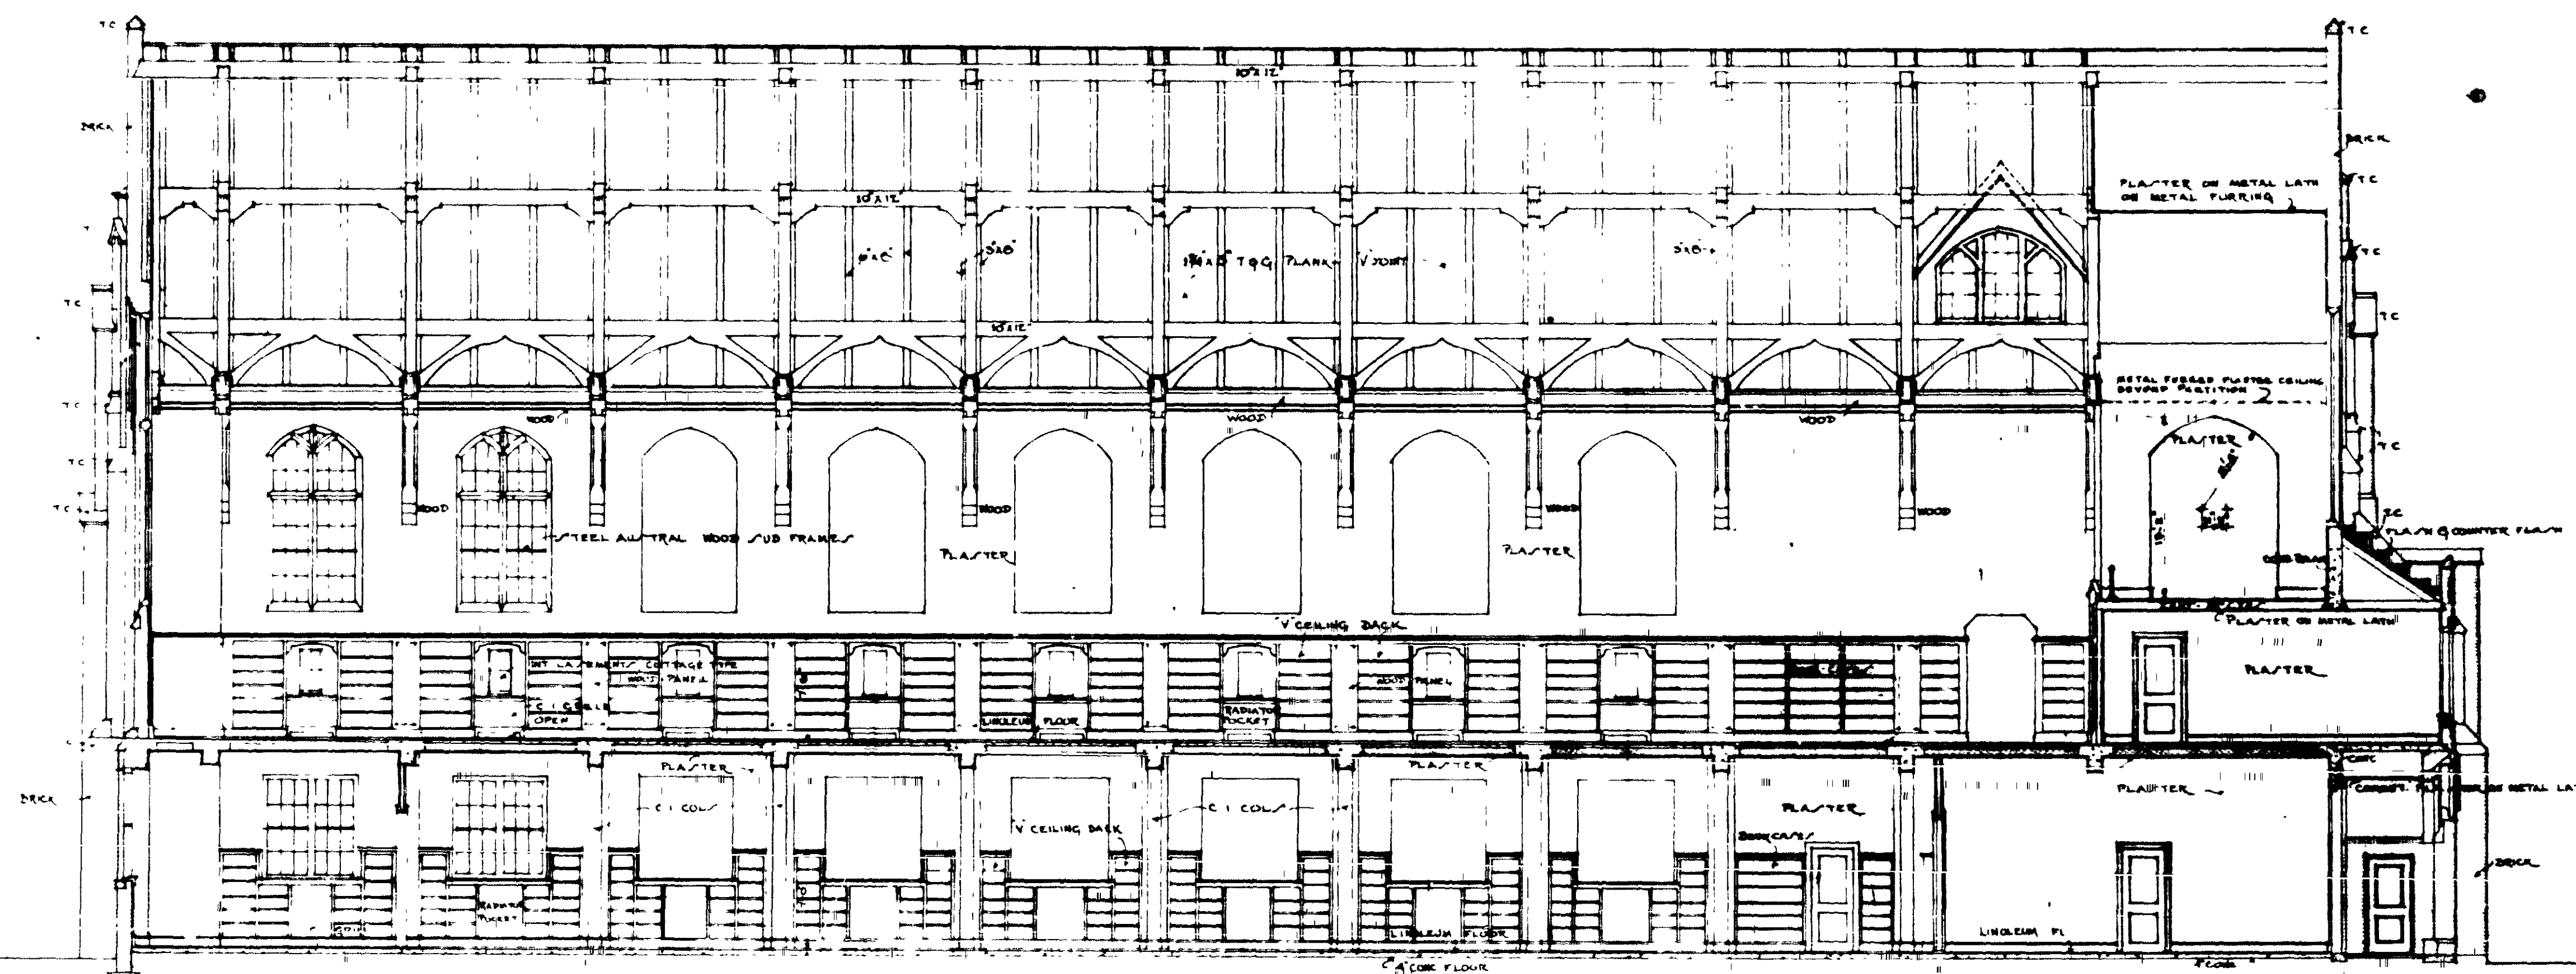



LONGITUDINAL SECTION (THRU MAIN READING ROOM)
SCALE 1/8" = 1'-0"

LIBRARY BUILDING
UNIVERSITY OF FLORIDA
GAINESVILLE - FLORIDA


FILE NO. 510
DRAWG. NO. 6
DATE JAN. 15, 1924
DRAWN BY L.C.
CHECKED BY
EDWARDS & SAYWARD - ARCHITECTS
101 MARQUETTE ST. - ATLANTA, GA.

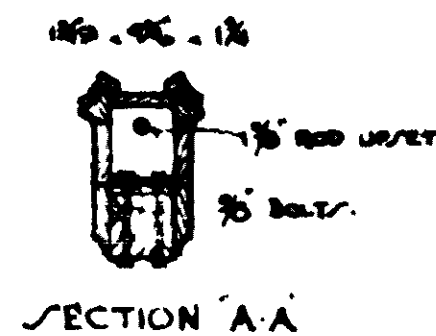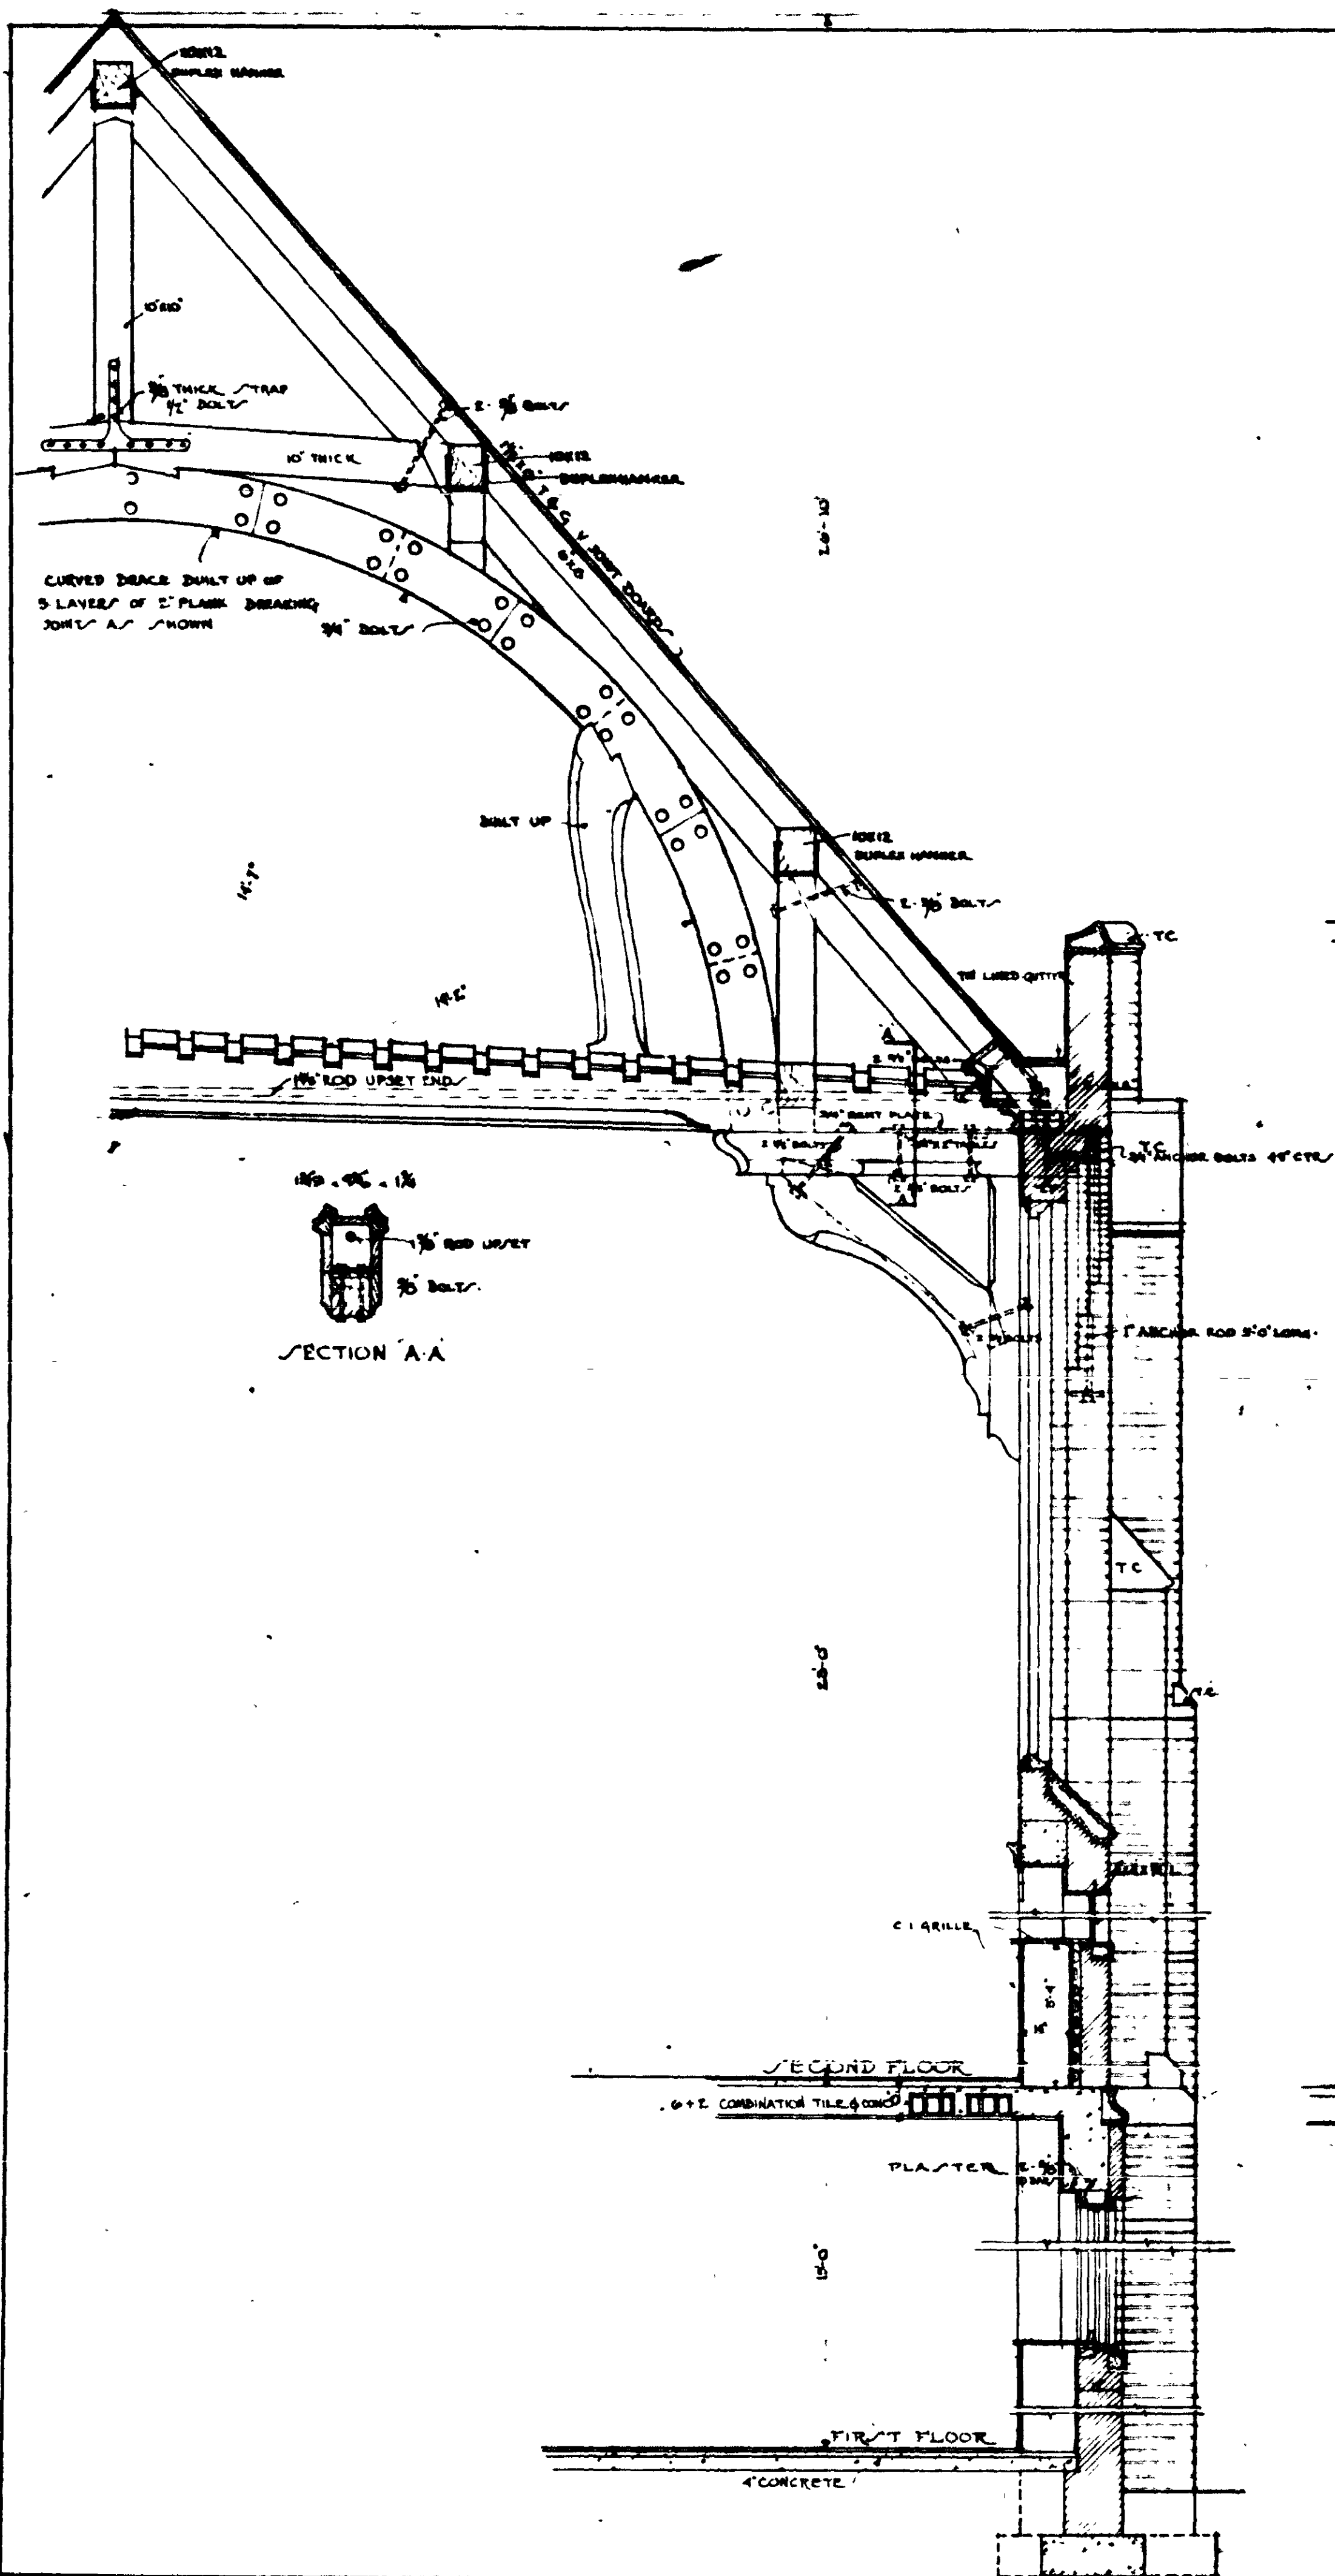


SECTION A-A

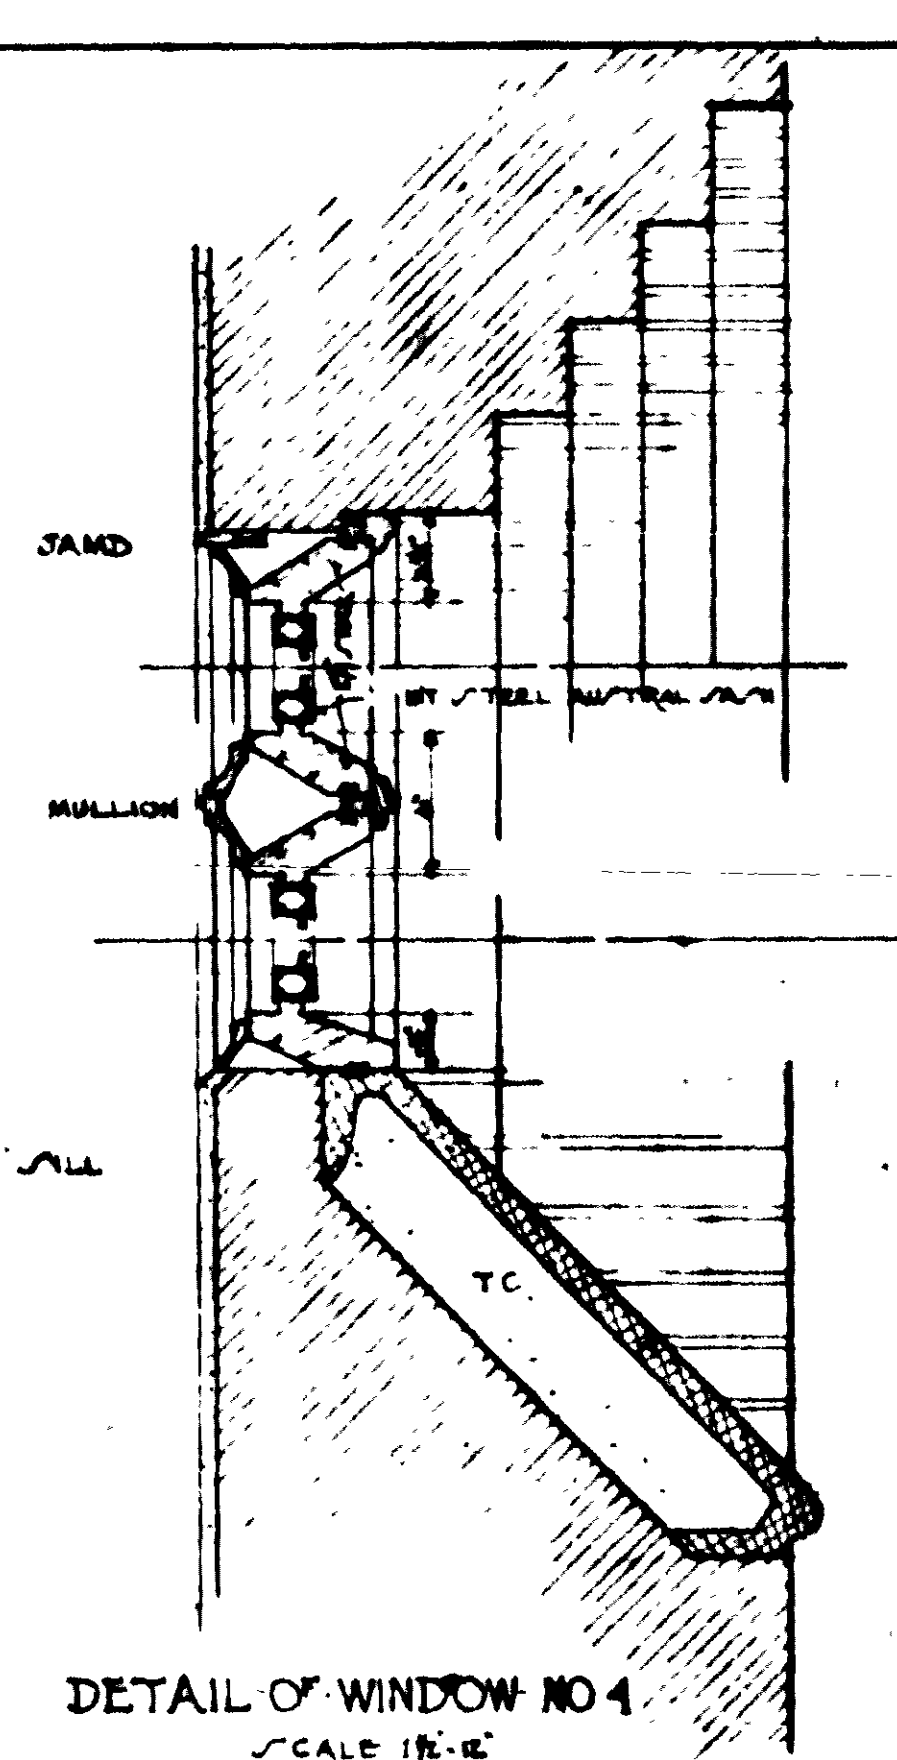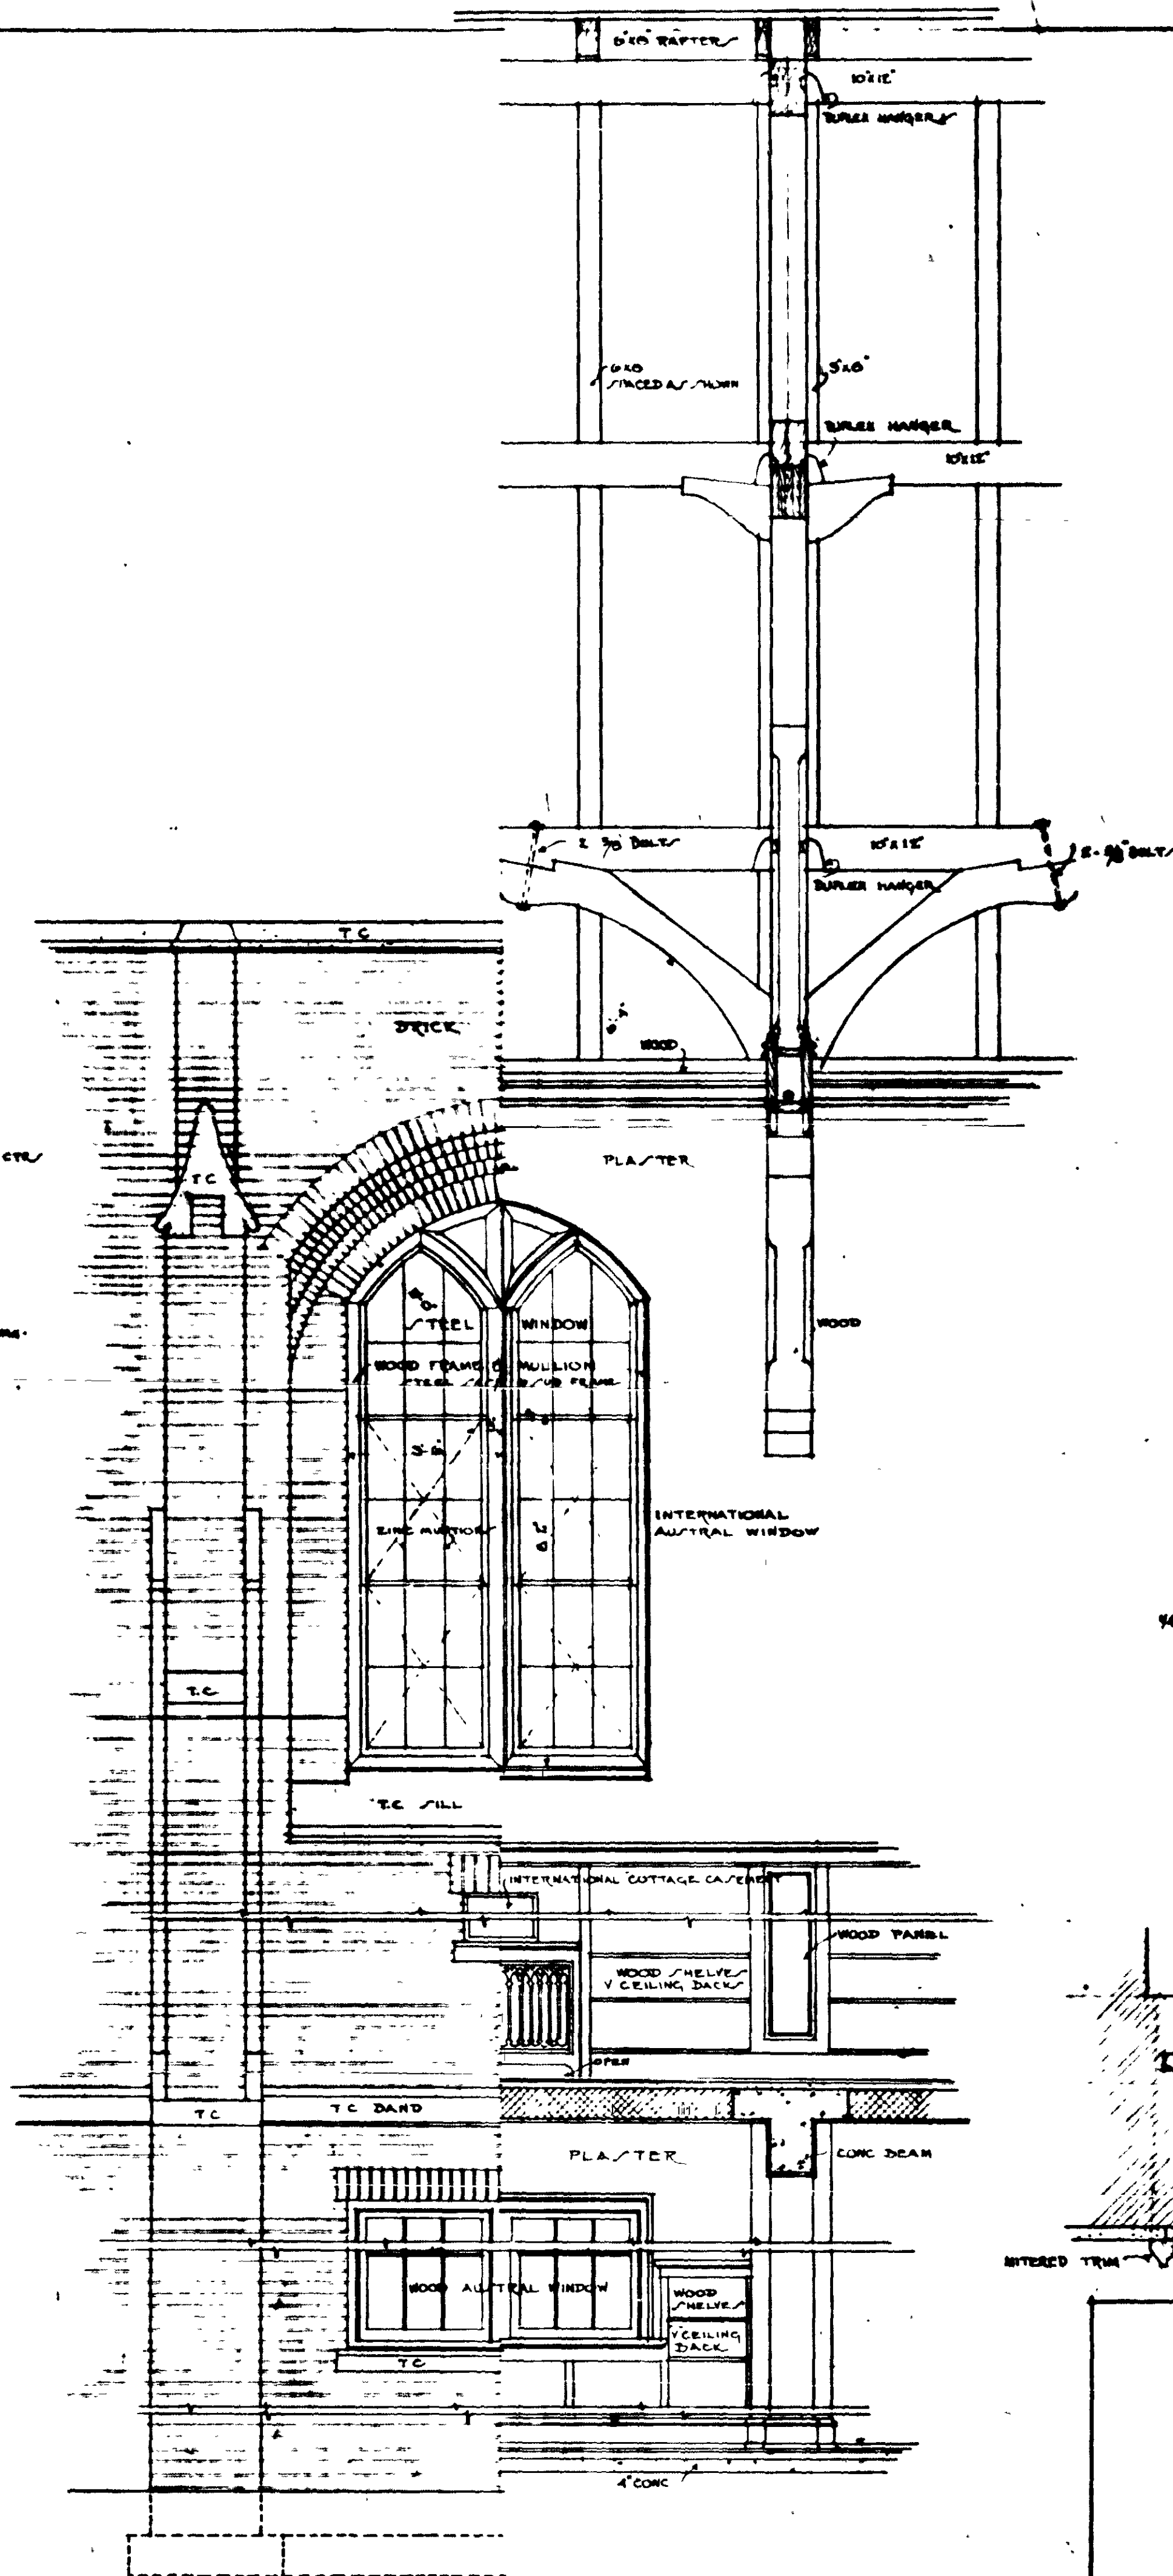

DETAIL OF WINDOW NO 4
SCALE 1/2"=1'

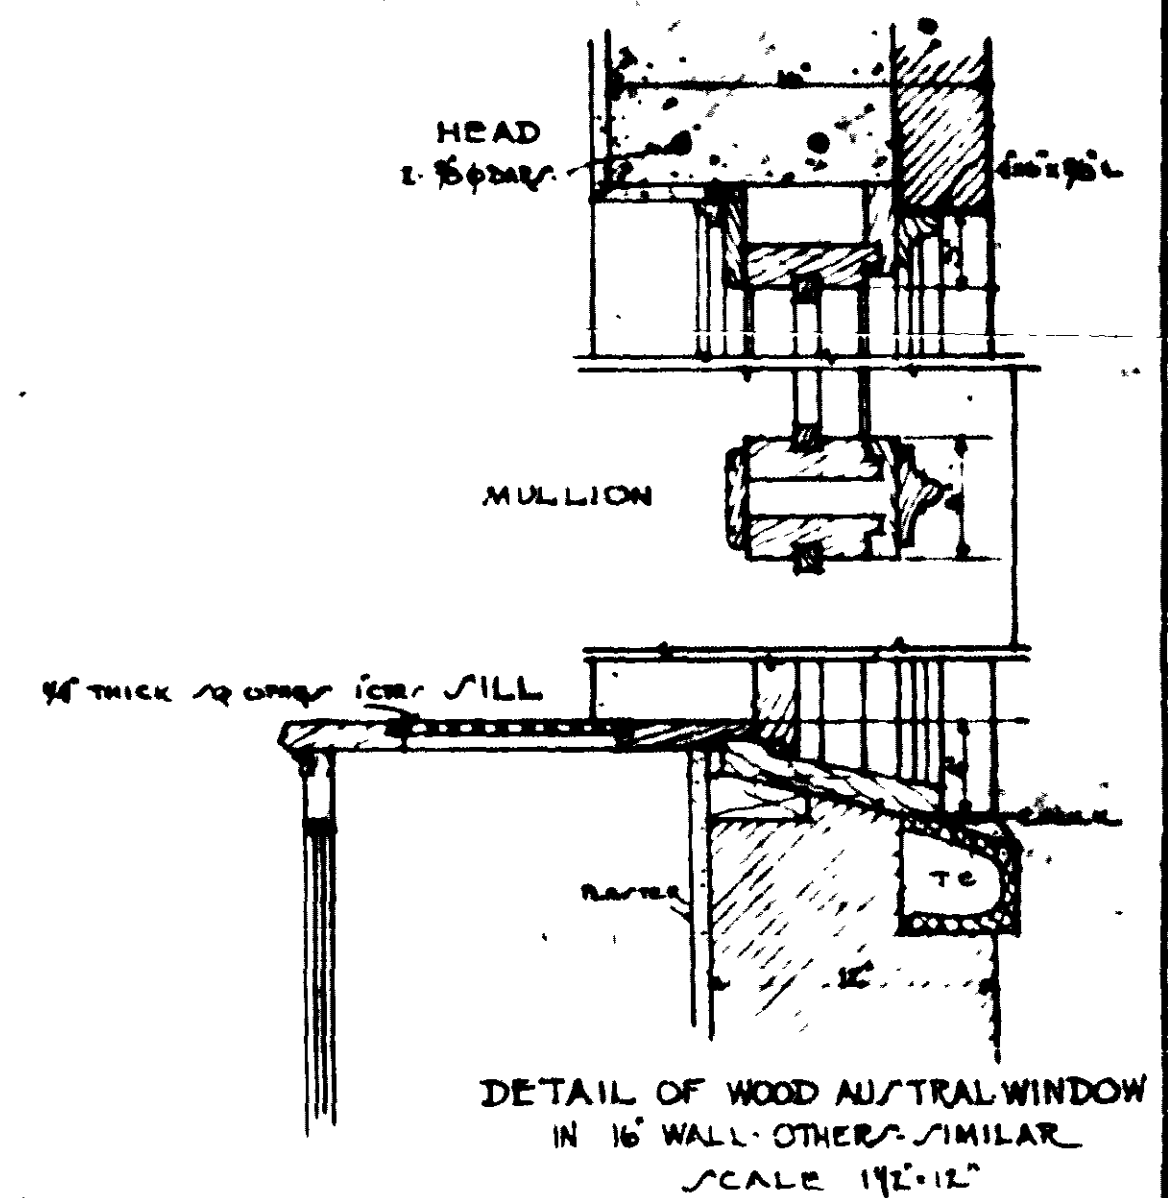


DETAIL OF WOOD AUSTRAL WINDOW
IN 16" WALL OTHERS SIMILAR
SCALE 1/2"=1'

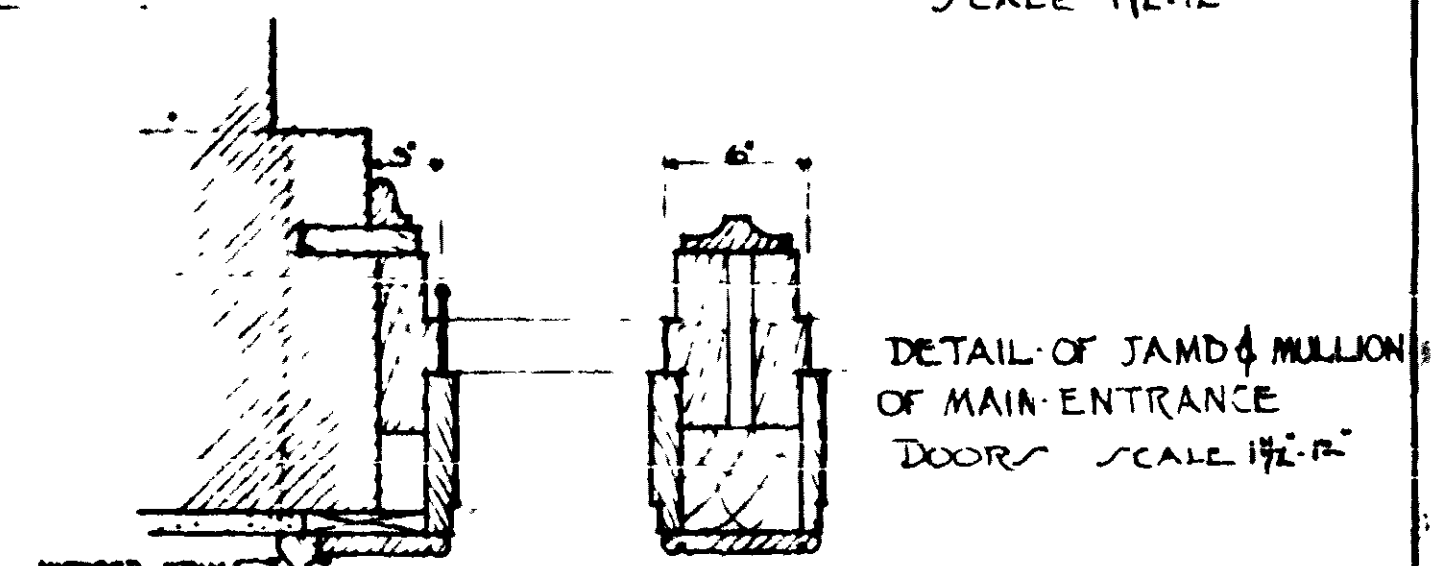

LIBRARY BUILDING
UNIVERSITY OF FLORIDA
GAINESVILLE - FLORIDA

FILE NO 520- DRAWN BY RGL
DRWG NO 7 CHECKED BY
DATE JAN 25 1924
EDWARDS & SAYWARD - ARCHITECTS
101 MARIETTA ST ATLANTA, GA.

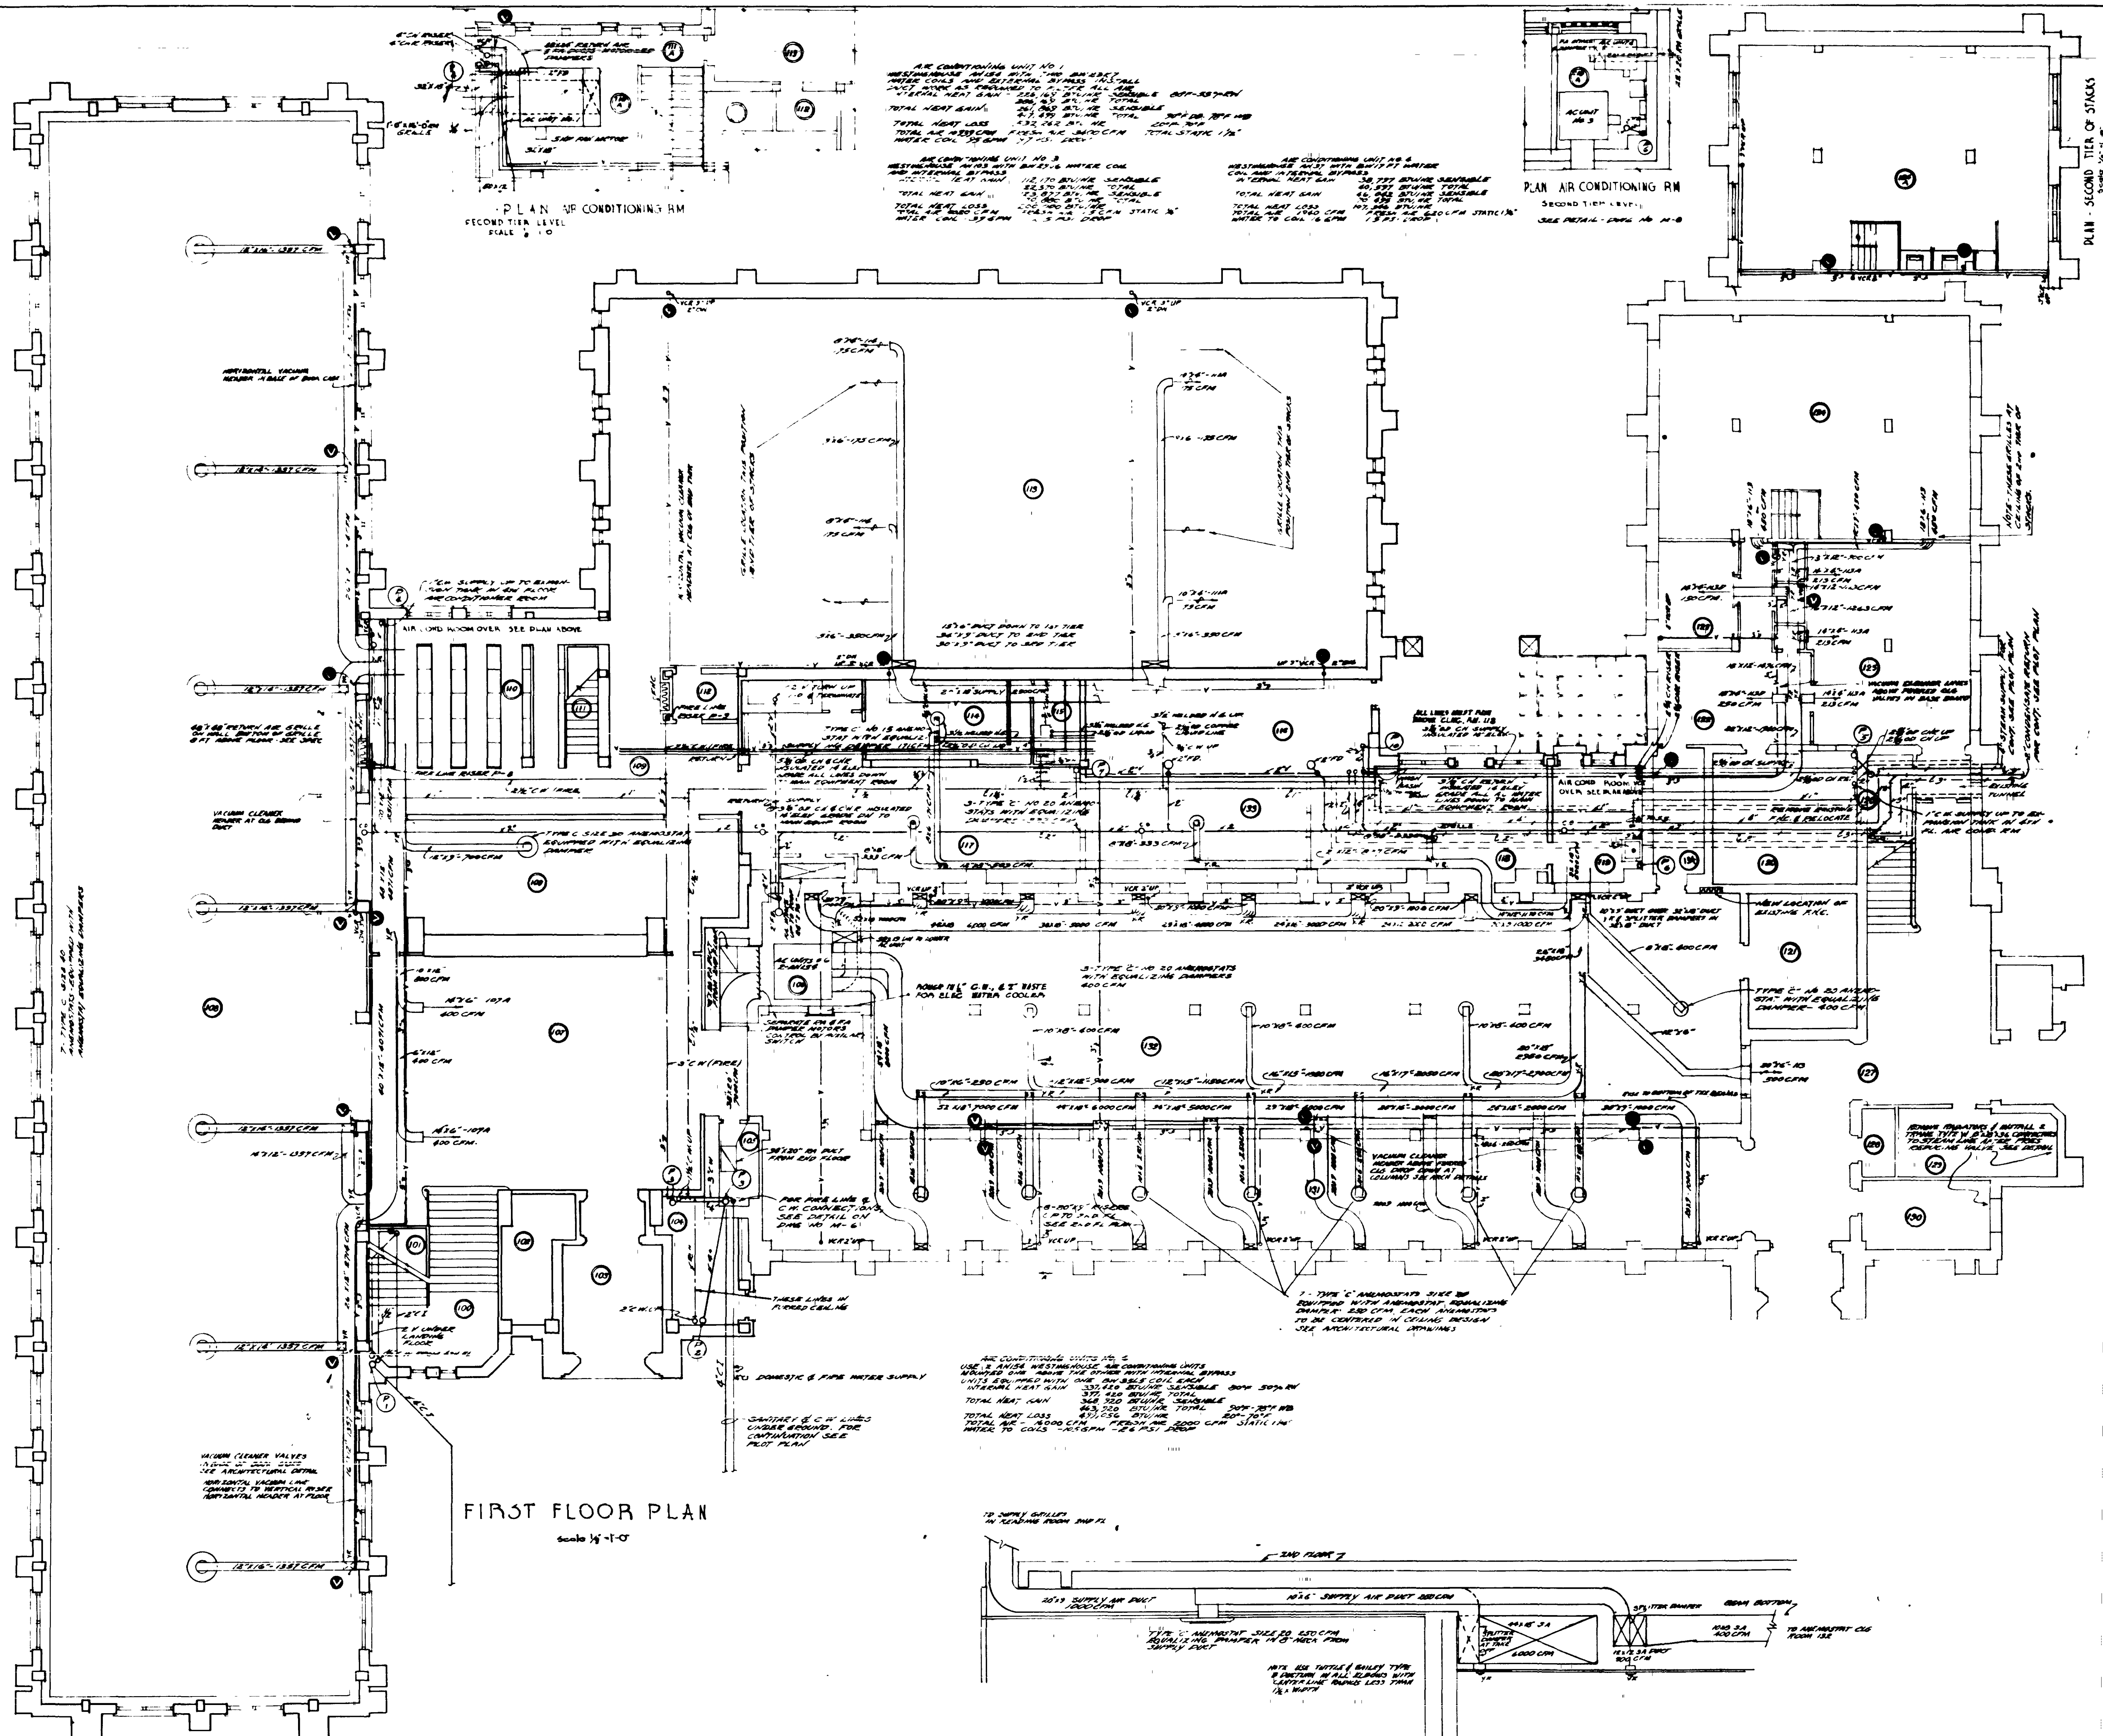

MECHANICAL SYMBOLS

	AIR MAIN PRESSURE STREAM
	AIR MAIN PRESSURE CONDENSATE RETURN
	COLD WATER SUPPLY
	SANITARY RETURN
	SANITARY VENT PIPING
	VACUUM CLEANING LINE
	CIRCULATING CHILLED OR HOT WATER FLOW
	CIRCULATING CHILLED OR HOT WATER RETURN
	PELUMING BUZZER
	FIRE LINE
	GATE VALVE
	CHECK VALVE
	TRAP CONTROL VALVE
	STRAINER
	UNION
	MECHANICAL TRAP
	LABORATORY
	WATER CLOSET
	URINAL
	SLOP SINK
	THERMOMETER WELL
	AUTOMATIC AIR VENT
	JOHN S. BULLENS REGULATING MODEL 80
	YOUNG CHAMBER REGULATING
	VACUUM DISER
	VACUUM HOSE CONNECTION
	FLOOR DRAIN

